
LEGEND

TYPE	LAMPS	DESCRIPTION	COLOUR /	CATALOGU				
ITPE	LAWIPS	DESCRIPTION	ACCESSORY	No				
L1	1W LED AT 500 CENTRES	24V DC IP65 FESTOON LIGHTING TO BE FIXED TO A 316 STAINLESS STEEL WIRE SUPPORT SYSTEM. LOCATE THE DRIVER IN A CONCEALED ACCESSIBLE POSITION NOTED ON THE AS CONSTRUCTED DOCUMENTS. CONNECT TO THE STRUCTURE / POLES PROVIDED AS PART OF THE BUILDING WORKS AS PER THE ARCHITECTURAL DOCUMENTATION. CONTROL EACH GROUP OF L1 LIGHTS VIA A MANUAL SWITCH LOCATED IN THE ADJACENT CONTAINER. CIRCUIT EACH GROUP OF L1 FITTINGS FROM THE ADJACENT CONTAINERS LIGHTING CIRCUIT.	BLACK CABLE AND FIXINGS 316 STAINLESS STEEL SUPPORT AND FIXINGS	GLOW WORM LIGHTING 1M (2 GLOBE/M) COMMERCIAL GRADE LED FESTOON LIGHTING				
L2	36W LED 4000K	SURFACE MOUNTED IP66 1200 LONG BATTEN C/W INTEGRAL DRIVER, OCCUPANCY SENSOR AND AN AS2293 NON MAINTAINED EMERGENCY PACK	LIGHT GREY	GAMMA STORN 1558-CCT-36 + SENSOR				
L3	36W LED 4000K	SURFACE MOUNTED IP66 1200 LONG BATTEN C/W INTEGRAL DRIVER AND OCCUPANCY SENSOR	LIGHT GREY	GAMMA STORN 1558-CCT-36 + SENSOR				
L4	13W 4000K LED	SURFACE MOUNTED 93 DEG BEAM CAN DOWNLIGHT C/W INTEGRAL DRIVER	WHITE TRIM	GAMMA ILLUMINATION TONDO 1325-4K-13W				
L5	RELOCATE THE EXISTING CEILING MOUNTED EXAMINATION LIGHT AND ASSOCIATED SWITCH CONFIRM THE FINAL POSITION ON SITE WITH THE OPERATOR.							
L6	28W 3000K LED	LIGHTING BOLLARD C/W INTEGRAL DRIVER AND A RAGBOLT FOOTING. CIRCUIT AND SWITCH THE L6 FITTINGS WITH THE ADJACENT L1 FITTINGS.	BLACK	GAMMA ILLUMINATION BOLO 1462-3K-28W				
L7	RELOCATE THE EXISTING OFFICE LIGHT AS INDICATED. CIRCUIT AND SWITCH THE L7 FITTING WITH THE ADJACENT L10 FITTING.							
L8	EXISTING RECESSED DOWNLIGHT TO REMAIN AS IS .							
L9	PROVIDE NEW RECESSED DOWNLIGHTS TO MATCH THE EXISTING L8 FITTING. CIRCUIT AND SWITCH THE L9 FITTINGS WITH THE L8 FITTING.							
L10	EXISTING OFFICE LIGHT TO REMAIN AS IS .							
L11	NEW TROFFER LIGHT TO MATCH THE EXISTING L10 LIGHT FITTINGS.							
ONE-WA	Y LIGHT SWITCH	ONE-WAY LIGHT SWITCH C/W CIRCUIT IDENTIFICATION ON THE FACEPLATE BEHIND THE SURROUND MOUNTED AT 1000mm AFFL UNLESS NOTED OTHERWISE.	WHITE	CLIPSAL C2000 SERIES 30USM				
TWO-WA	AY LIGHT SWITCH	TWO -WAY LIGHT SWITCH C/W CIRCUIT IDENTIFICATION ON THE FACEPLATE BEHIND THE SURROUND MOUNTED AT 1000mm AFFL UNLESS NOTED OTHERWISE.	WHITE	CLIPSAL C2000 SERIES 30USM				
PROXIM SWITCH	ITY DETECTOR (PD)	ADJUSTABLE FLUSH RECESSED 360 DEGREE PIR PRESENCE DETECTOR TO OPERATE THE ASSOCIATED LIGHTS FOR A PRE-SET AMOUNT OF TIME. ADJUST THE TIME AND SENSITIVITY ON SITE AS DIRECTED BY THE ENGINEER. SUBMIT DETAILS OF THE MOVEMENT DETECTOR SWITCH FOR APPROVAL PRIOR TO ORDERING	WHITE	CLIPSAL				
COMMUI	NICATIONS OUTLET	RJ45 CAT-6 COMMUNICATIONS OUTLET, CABLED BACK TO A PATCH PANEL IN THE EXISTING COMMUNICATIONS RACK VIA 4-PAIR CAT-6 UTP CABLE. IT IS ACCEPTABLE TO UTILISE THE EXISTING OFFICE COMMUNICATIONS OUTLETS / CABLE IF THEY ARE IN APPROPIATE CONDITION AND CAN BE RELOCATED	WHITE	CLIPSAL C2000 SERIES				

LEGEND

	THE LIGHT FITTING SUPPLIER CONTACT DETAILS MAY BE AVAILABLE ON THE EDG WEBSITE VIA THE FOLLOWING LINK www.edg.net.au/Links/Lighting.htm							
	TYPE	LAMPS	DESCRIPTION	COLOUR / ACCESSORY	CATALOGUE No			
4	SINGLE F	POWER OUTLET	SINGLE POWER OUTLET. CONFIRM THE POSITION ON SITE WITH THE OPERATOR. RATING 10A U.N.O.	WHITE	CLIPSAL C2000 SERIES			
•	DOUBLE POWER OUTLET		DOUBLE POWER OUTLET. CONFIRM THE POSITION ON SITE WITH THE OPERATOR. RATING 10A U.N.O.	WHITE	CLIPSAL C2000 SERIES			
HD	HAND DRYER CONNECTION (HD)		DIRECT CONNECT THE HAND DRYER SUPPLIED BY THE BUILDER VIA A CONCEALED CABLE.					
ø	SIGN CONNECTION		COORDINATE THE LOCATION AND CONNECTION WITH THE SIGN CONTRACTOR ENSURING THE GPO / ISOLATORS ARE PROVIDED WITH APPROPRIATE WEATHER PROTECTION AND ARE CONCEALED FROM VIEW.					
Ø	SINGLE-PHASE ISOLATOR		SINGLE-PHASE WEATHERPROOF ISOLATOR CONNECTED TO THE ROOF MOUNTED EXHAUST FAN.					
Ø	THREE-PHASE ISOLATOR		THREE-PHASE CONNECTION TO THE CONTAINER DISTRIBUTION BOARD COORDINATE THE LOCATION AND CABLE ACCESS WITH EH CONTAINER SUPPLIER.					
DB-1	DB-1		RELOCATE THE EXISTING DISTRIBUTION BOARD DB-1 AS NOMINATED. PROVIDE NEW SWITCHGEAR AND CONTROLS WITHIN DB-1 OF THE SAME BRAND AND TYPE AS THE EXISTING AS PER THE CIRCUIT DESCRIPTIONS BELOW. UPDATE THE SCHEDULE AT PRACTICAL COMPLETION. PROVIDE DB-1 WITH AN AS2293 TEST FACILITY. UPGRADE DB-1 AS NECESSARY TO ACCOMMODATE THE ADDITIONAL CIRCUITS.					
DB-1 - P1	CIRCUIT DB-1 - P1		PROVIDE A NEW CIRCUIT DB-1 - P1 AS A SINGLE PHASE 20 AMP RCBO PROTECTED 2.5MM CIRCUIT SUPPLYING THE HAND DRYERS.					
DB-1 - P2	CIRCUIT DB-1 - P2		PROVIDE A NEW CIRCUIT DB-1 - P2 AS A SINGLE PHASE 20 AMP RCBO PROTECTED 2.5MM CIRCUIT SUPPLYING THE HAND DRYERS.					
DB-1 - P3	CIRCUIT DB-1 - P3		PROVIDE A NEW CIRCUIT DB-1 - P3 AS A SINGLE PHASE 20 AMP RCBO PROTECTED 2.5MM CIRCUIT CONTROLLED VIA A 24 / 7 TIME CLOCK TO SUPPLY THE ROOF MOUNTED EXHAUST FAN.					
DB-1 - P4	I CIRCIIII DB-1 - P4		PROVIDE A NEW CIRCUIT DB-1 - P4 AS A THREE PHASE 40 AMP 4C 10MM CIRCUIT RUN UNDERGROUND IN CONDUIT BETWEEN THE BUILDINGS SUPPLYING THE COFFEE CONTAINER DISTRIBUTION BOARD.					
DB-1 - P5	CIRCUIT DB-1 - P5		PROVIDE A NEW CIRCUIT DB-1 - P5 AS A THREE PHASE 40 AMP 4C 10MM CIRCUIT RUN UNDERGROUND IN CONDUIT BETWEEN THE BUILDINGS SUPPLYING THE BAR CONTAINER DISTRIBUTION BOARD.					
DB-1 - P6	CIRCUIT	DB-1 - P6	PROVIDE A NEW CIRCUIT DB-1 - P6 TO SUPPLY THE IRRIGATION PUMP. CONFIRM THE NUMBER OF PHASES AND CURRENT RATING ON SITE WITH THE IRRIGATION PUMP SUPPLIER.					
DB-1 - L1	CIRCUIT	DB-1 - L1	PROVIDE A NEW CIRCUIT DB-1 - L1 AS A SINGLE PHASE 20 AMP RCBO PROTECTED 2.5MM CIRCUIT RUN UNDERGROUND IN CONDUIT BETWEEN THE BUILDINGS SUPPLYING THE ILLUMINATED SIGNAGE. CONTROL THE CIRCUIT SUCH THAT IT AUTOMATICALLY SWITCHES ON VIA A PE CELL 30 MINUTES PRIOR TO DUSK AND OF VIA A TIME CLOCK. CONFIRM THE TIME WITH THE OPERATOR.					
DB-1 - L2	CIRCUIT	DB-1 - L2		TIDE A NEW CIRCUIT DB-1 - L2 AS A SINGLE PHASE 20 AMP RCBO PROTECTED 2.5MM LIGHTING CIRCUIT. IT IS PTABLE TO UTILISE AN EXISTING LIGHTING CIRCUIT IF IT HAS SUFFICIENT CAPACITY.				

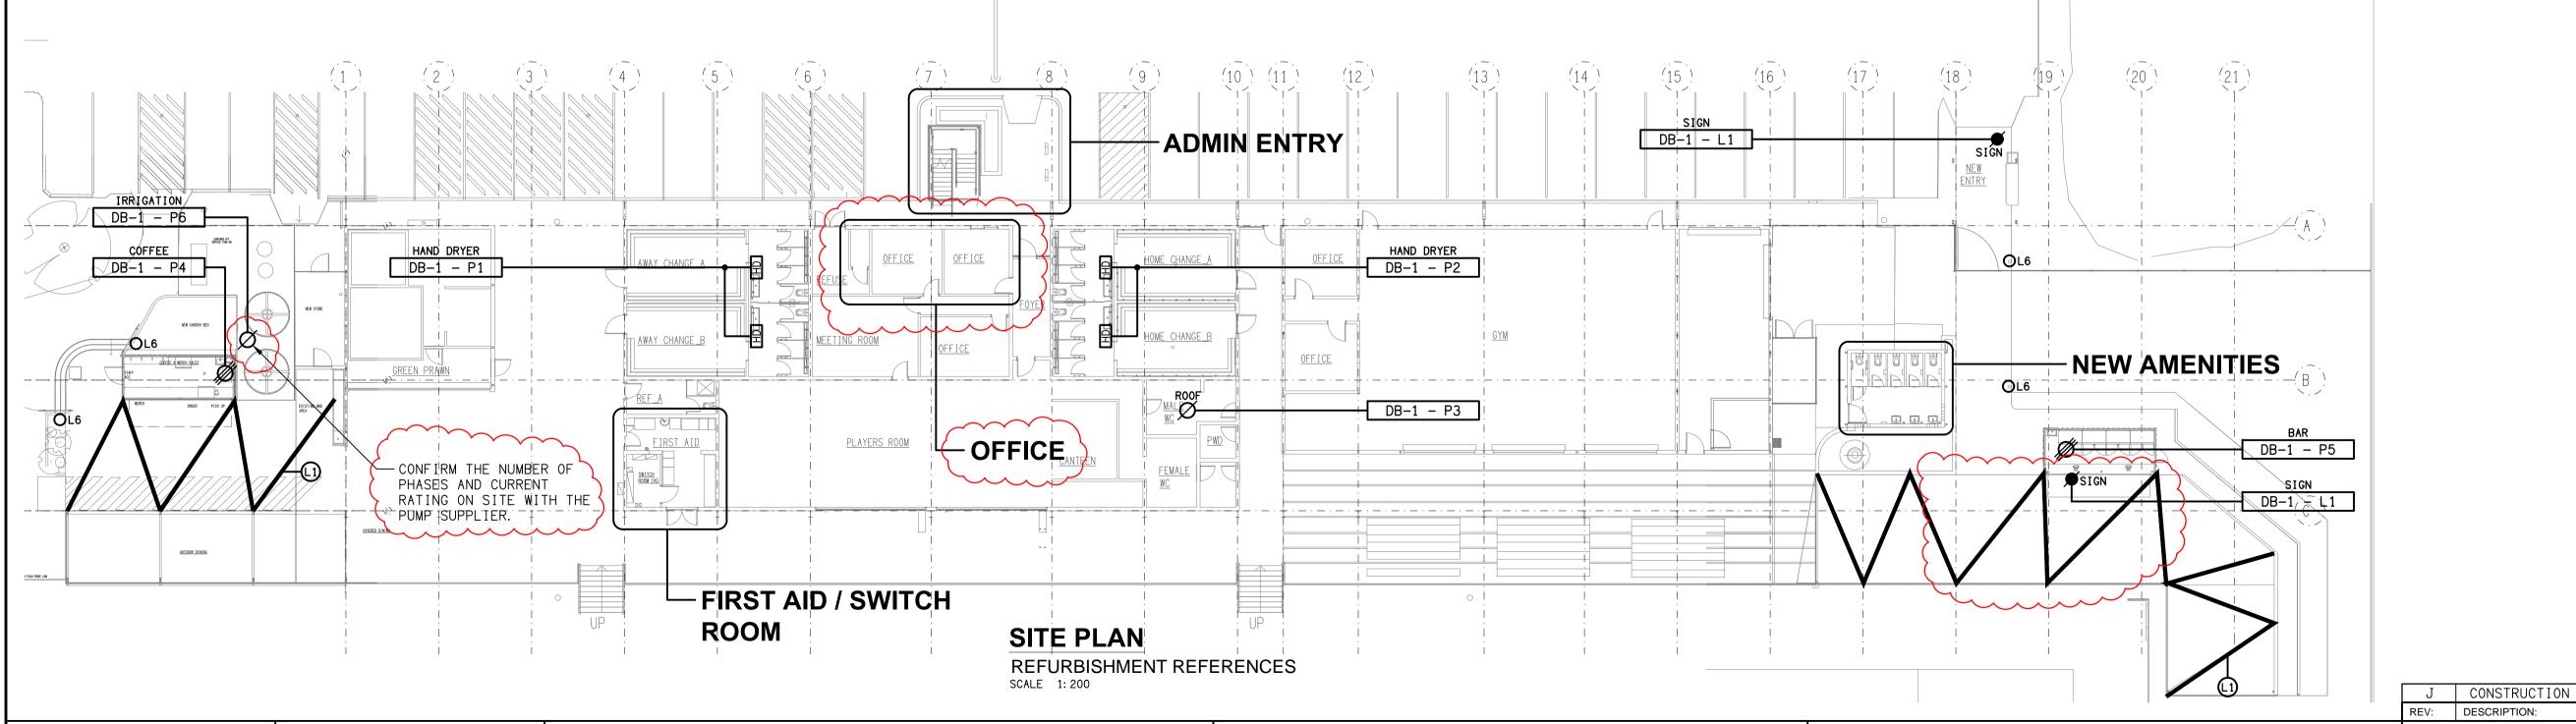

ELECTRICAL DESIGN GROUP

ELECTRICAL BUILDING SERVICES CONSULTANTS

SUNNYBANK RUGBY CLUB

ELECTRICAL SERVICES
LEGEND & SITE PLAN

SCALE:
1:200 AT A1 PROJECT NO:

C3377

PROJECT NO: DRAWING NO: REVISION: J

28/03/2025 DATE:

ELECTRICAL DESIGN GROUP BRISBANE
PTY LTD
ACN 092 710 793

TRADING AS:
ELECTRICAL DESIGN GROUP

THE COPYRIGHT OF THIS DRAWING
REMAINS THE PROPERTY OF THE
ELECTRICAL DESIGN GROUP.

USE FIGURED DIMENSIONS
IN PREFERENCE TO SCALE.

ALL DIMENSIONS TO BE VERIFIED ONSITE.

P.O.Box 15, Sherwood Q.4075 Phone: (07) 3278 4375 Email: brisbane@edg.net.au Web: www.edg.net.au

162 GRANADILLA STREET, SUNNYBANK

GOLD COAST