


LEGEND


- ELECTRICAL SERVICES SWITCHBOARD.
- SWITCHBOARD / CONTROL PANEL NOT PROVIDED AS PART OF THE ELECTRICAL SUBCONTRACT.
- SINGLE POWER OUTLET.
- DOUBLE POWER OUTLET.
- SPECIAL PURPOSE POWER OUTLET.
- SINGLE PHASE ISOLATOR.
- THREE PHASE ISOLATOR.
- ONE-WAY LIGHT SWITCH.
- TWO-WAY LIGHT SWITCH.
- DALI LIGHT SWITCH.
- CIRCUIT LINE.
- SWITCH LINE.
- DB-x - Py POWER CIRCUIT DESIGNATION. DENOTES DB AND CIRCUIT.
- ELECTRICAL EQUIPMENT AS NOTED.
- RJ45 COMMUNICATIONS OUTLET.
- PA MULTI-TAP CONE SPEAKER.
- REFER TO DETAIL NOTED FOR THE AREA SHOWN HATCHED. ADDITIONAL OUTLETS & FITTINGS MAY BE SHOWN ON DETAIL.
- E1: RECESSED LED EMERGENCY LIGHT.
- E2: WALL MOUNTED LED EMERGENCY LIGHT.
- EX: EMERGENCY LED EXIT LIGHT.
- L1: 300 x 1200 LED FLAT PLATE FITTING.
- L2: RECESSED DOWNLIGHT, DIMMABLE.
- L3: RECESSED DOWNLIGHT.
- L4: RECESSED DOWNLIGHT.
- L5: RECESSED ADJUSTABLE DOWNLIGHT.
- L6: 3000 LONG RECESSED 35 x 35 LED EXTRUSION LIGHT.
- L7: 2000 LONG RECESSED 35 x 35 LED EXTRUSION LIGHT.
- L8: 1200 LONG RECESSED 35 x 35 LED EXTRUSION LIGHT.

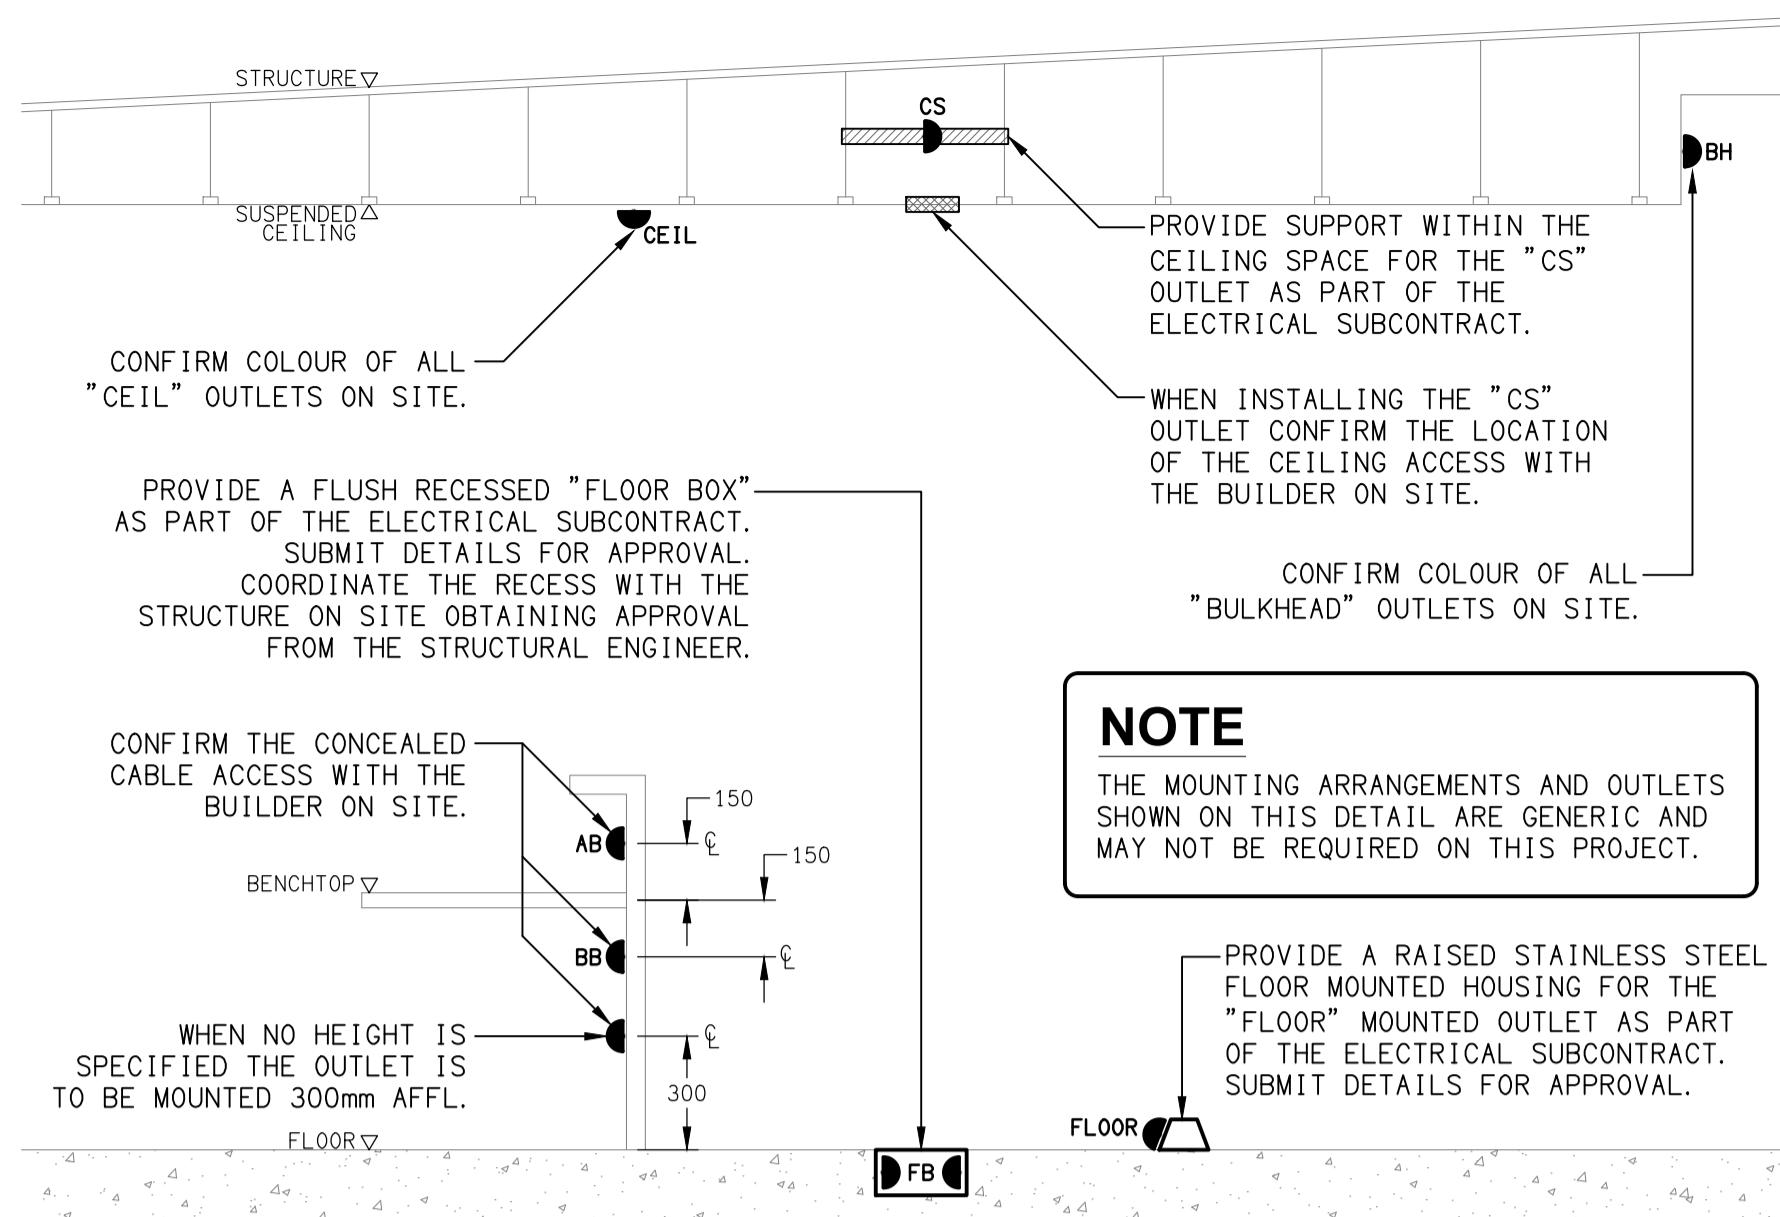


DETAIL
TYPICAL OUTLET MOUNTINGS
NOT TO SCALE

EQUIPMENT:

- TEST - TEST PUSH BUTTON MOUNTED ON THE DISTRIBUTION BOARD ESCUTCHEON.
- RESET - RESET PUSH BUTTON MOUNTED ON THE DISTRIBUTION BOARD ESCUTCHEON.
- LAMP - AMBER TEST INDICATING LAMP MOUNTED ON THE DISTRIBUTION BOARD ESCUTCHEON.
- Ta - ADJUSTABLE 0-3 HOUR TIMED RELAY.
- Tb - 15 MINUTE RUN-ON TIMER TO OPERATE UPON THE RETURN OF MAINS POWER.
- Cx - CONTACTOR x.
- CRx - CONTROL RELAY x.
- Rx - RELAY x.

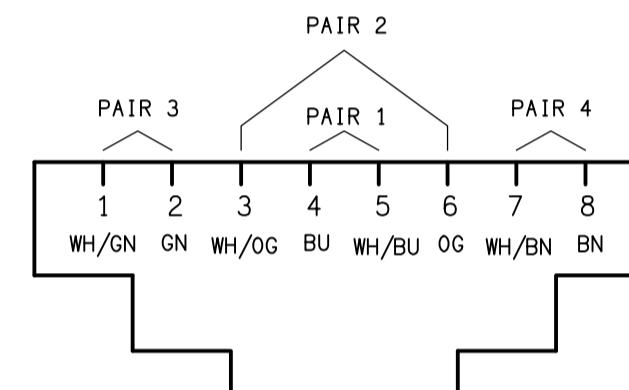


SCHEMATIC
RJ45 PINOUT CONFIGURATION
NOT TO SCALE

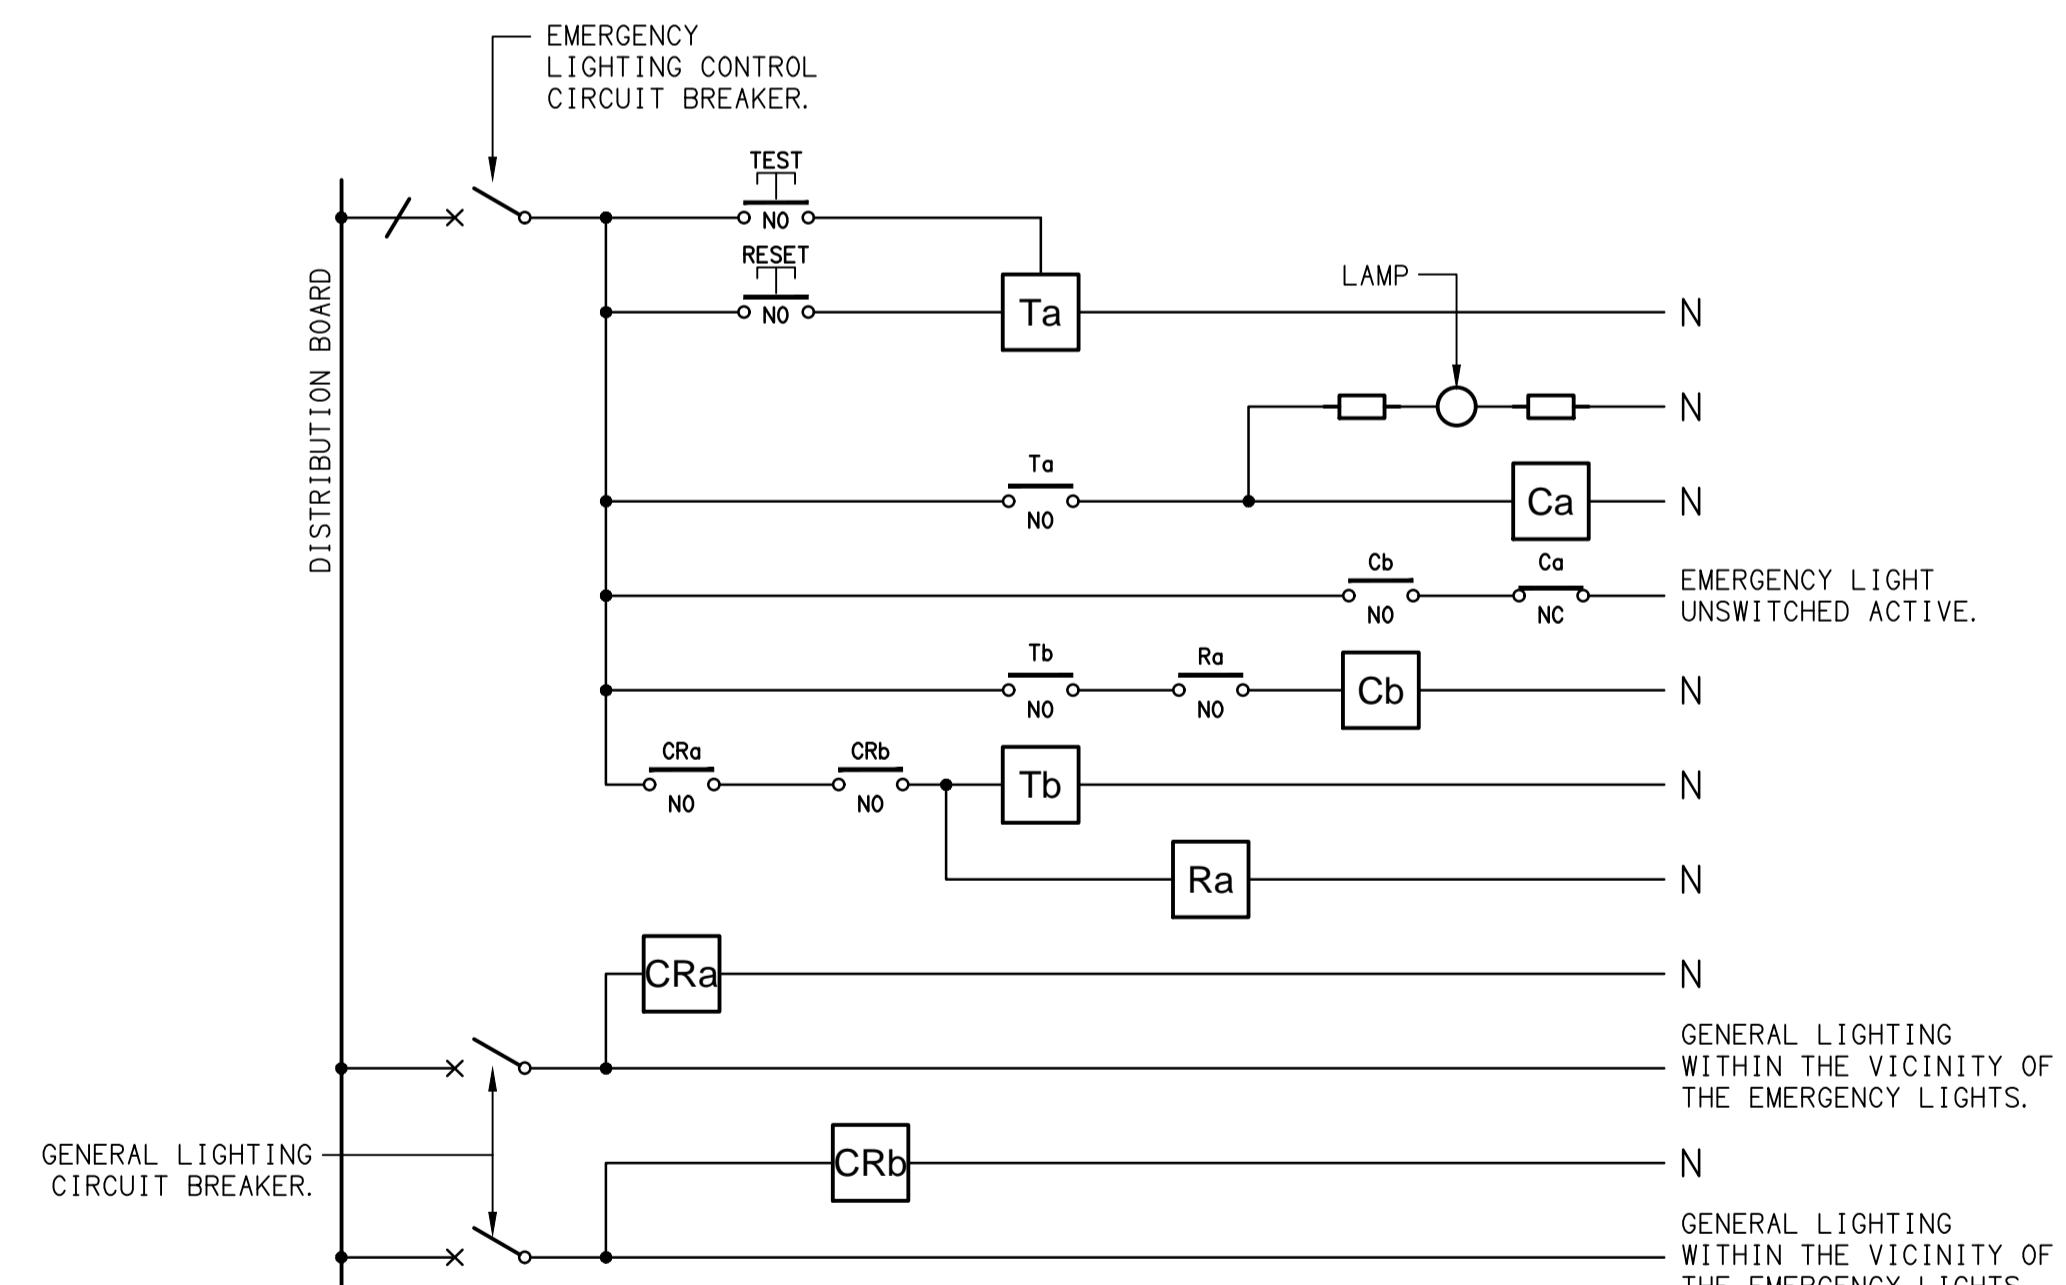

SCHEMATIC
EMERGENCY LIGHTING
NOT TO SCALE

NOTES

1. THE EMERGENCY LIGHT UNSWITCHED ACTIVE / GENERAL LIGHTING SWITCHED ACTIVE CIRCUIT ARRANGEMENT AND CONTROL IS TYPICAL FOR ALL CIRCUITS SUPPLYING EMERGENCY LIGHTS.
2. PROVIDE ADDITIONAL CONTROL RELAYS (CRx) CONFIGURED AS PER CRA AND CRb FOR ALL ADDITIONAL LIGHTING CIRCUITS THAT SUPPLY LIGHTS IN THE VICINITY OF THE EMERGENCY LIGHTS.

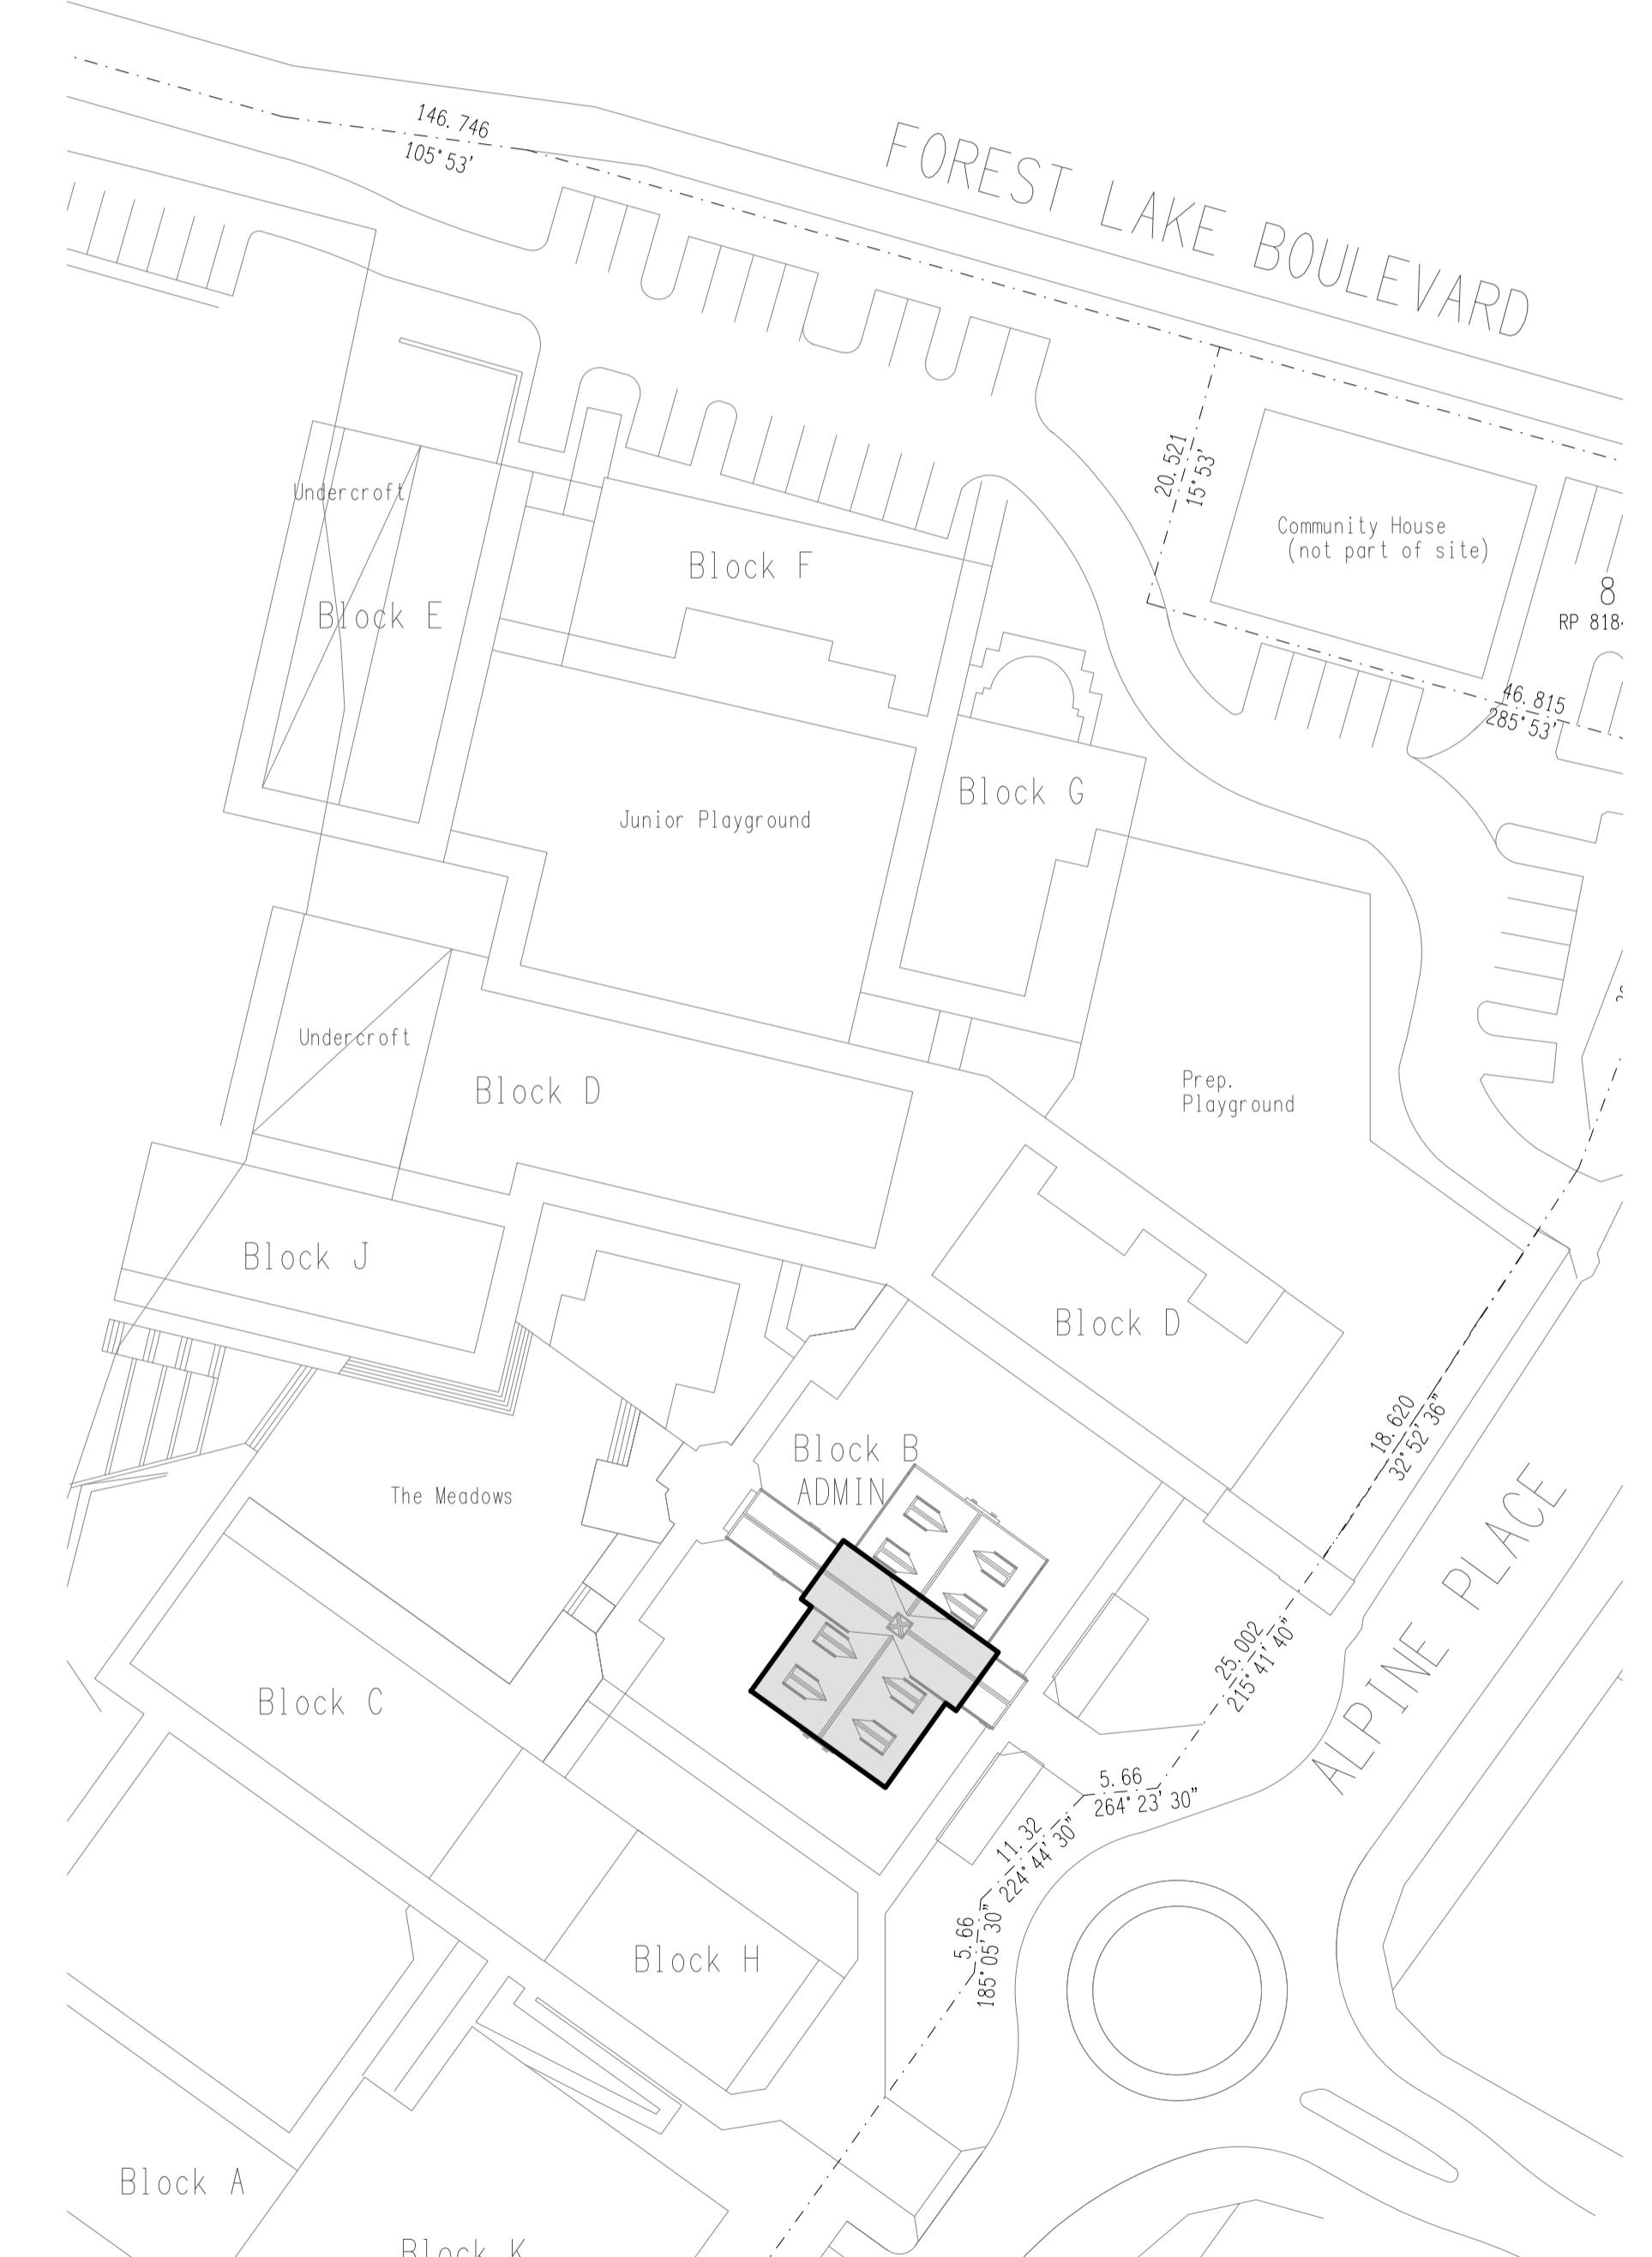

SITE PLAN

ADMINISTRATION BUILDING UPGRADE
SCALE: 1:500

E	CONSTRUCTION	16/12/2025
REV:	DESCRIPTION:	DATE:
DRAWING: ELECTRICAL SERVICES LEGEND, DETAILS & SITE PLAN		
SCALE: 1:500 UNO AT A1 PROJECT NO: C3613a DRAWING NO: E01 REVISION: E		