


REFER TO DRAWING C3760a-E05.dwg FOR
ADDITIONAL JOINERY & WALL LIGHTING.

**ALL EXISTING ELECTRICAL
SERVICES WITHIN THIS DASH
LINED AREA TO BE REMOVED,
UNLESS NOTE OTHERWISE.**

— REMOVE THE EXISTING EMERGENCY LIGHTS, EXIT LIGHTS, FIRE DETECTORS AND FIRE ALARM SPEAKERS IN THIS AREA. REPLACE ALL EXISTING CONCEALED SPACE FIRE DETECTORS IN THIS AREA.

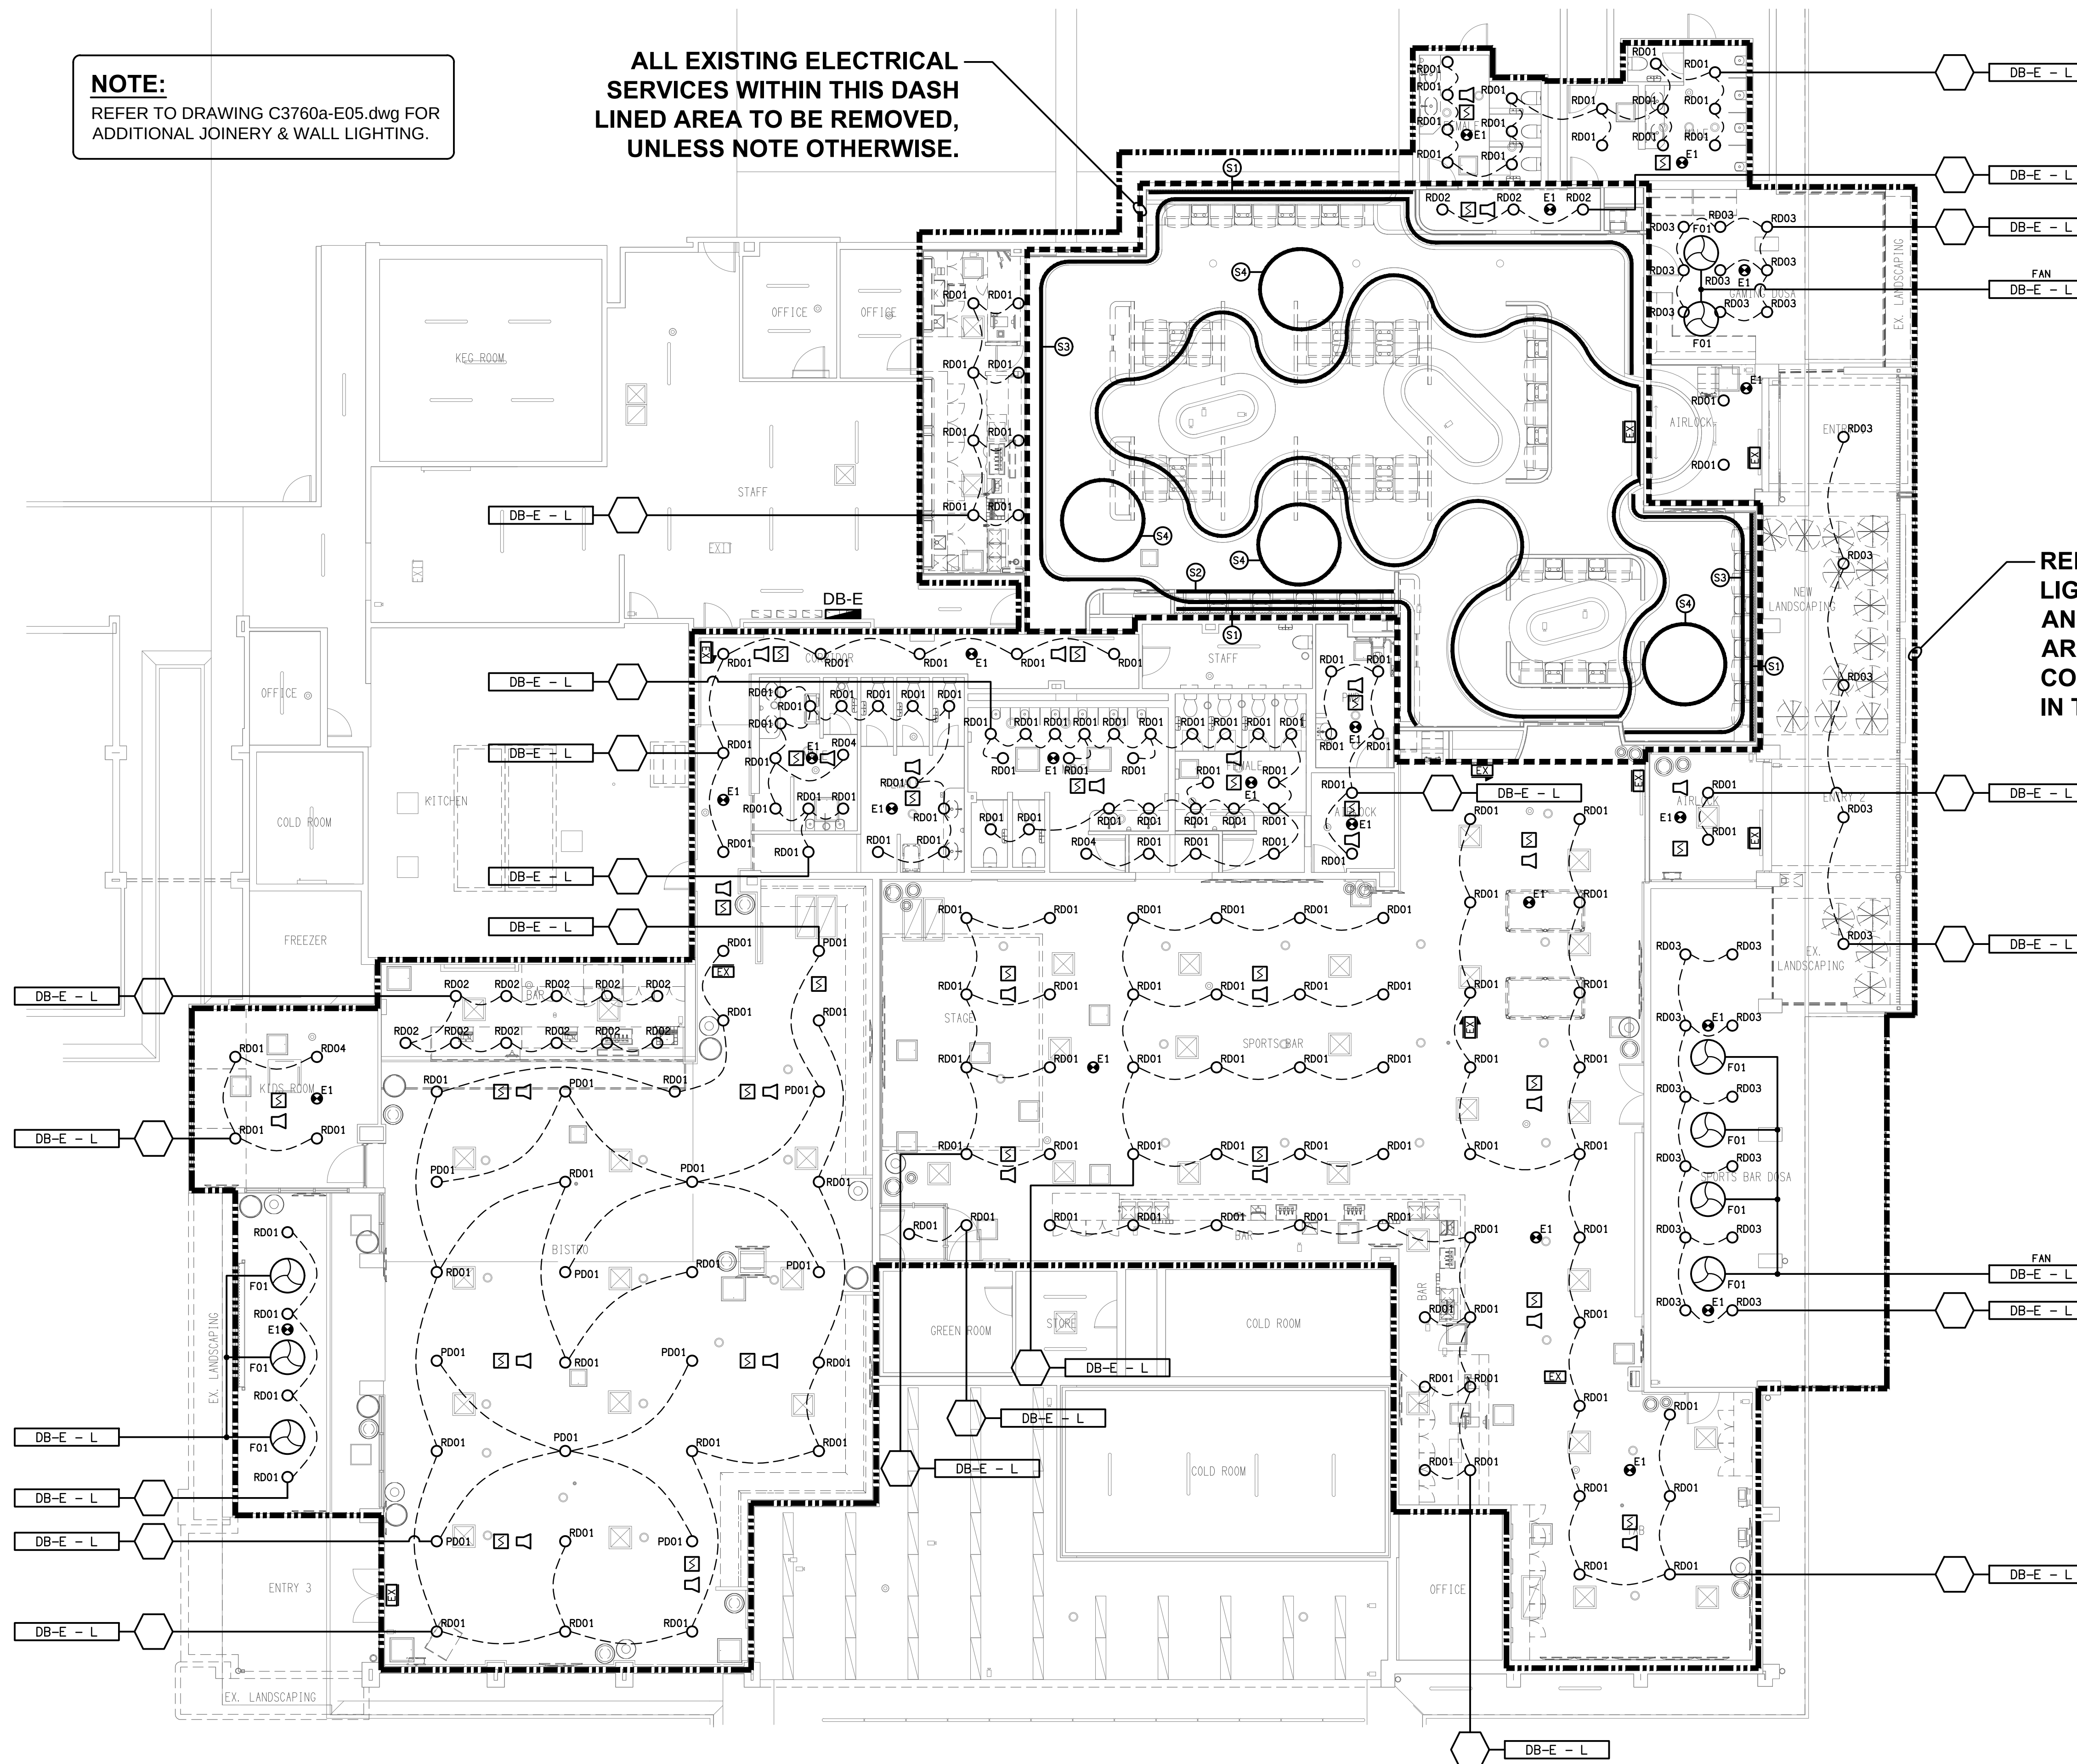

ELECTRICAL DESIGN GROUP BRISBANE PTY LTD ACN 092 710 793 TRADING AS: ELECTRICAL DESIGN GROUP	THE COPYRIGHT OF THIS DRAWING REMAINS THE PROPERTY OF THE ELECTRICAL DESIGN GROUP. USE FIGURED DIMENSIONS IN PREFERENCE TO SCALE. ALL DIMENSIONS TO BE VERIFIED ONSITE.			 ELECTRICAL DESIGN GROUP ELECTRICAL BUILDING SERVICES CONSULTANTS BRISBANE GOLD COAST P.O.Box 15, Sherwood Q.4075 Phone: (07) 3278 4375 Email: triscane@edg.net.au Web: www.edg.net.au	PROJECT: DALRYMPLE HOTEL 310 BAYSWATER ROAD, GARBUTT, QUEENSLAND	DRAWING: ELECTRICAL SERVICES REFLECTED CEILING PLAN SCALE: 1:100 UNO AT A1	PROJECT NO: C3760a	DRAWING NO: E04	REVISION: A
--	--	--	--	--	---	--	--------------------------------------	-----------------------------------	-------------------------------