

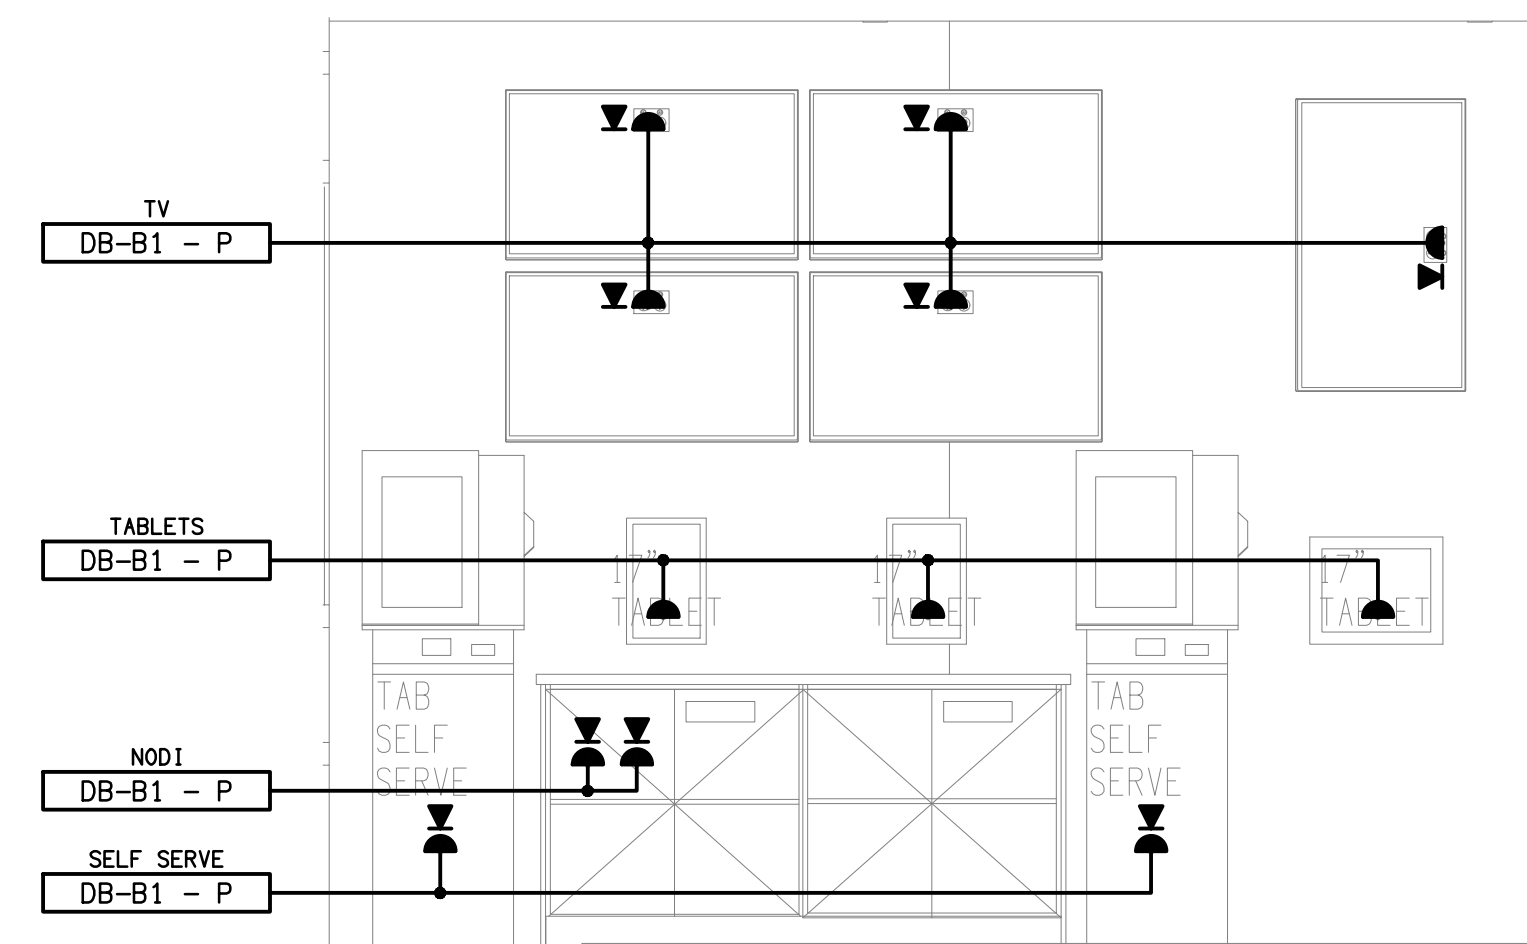


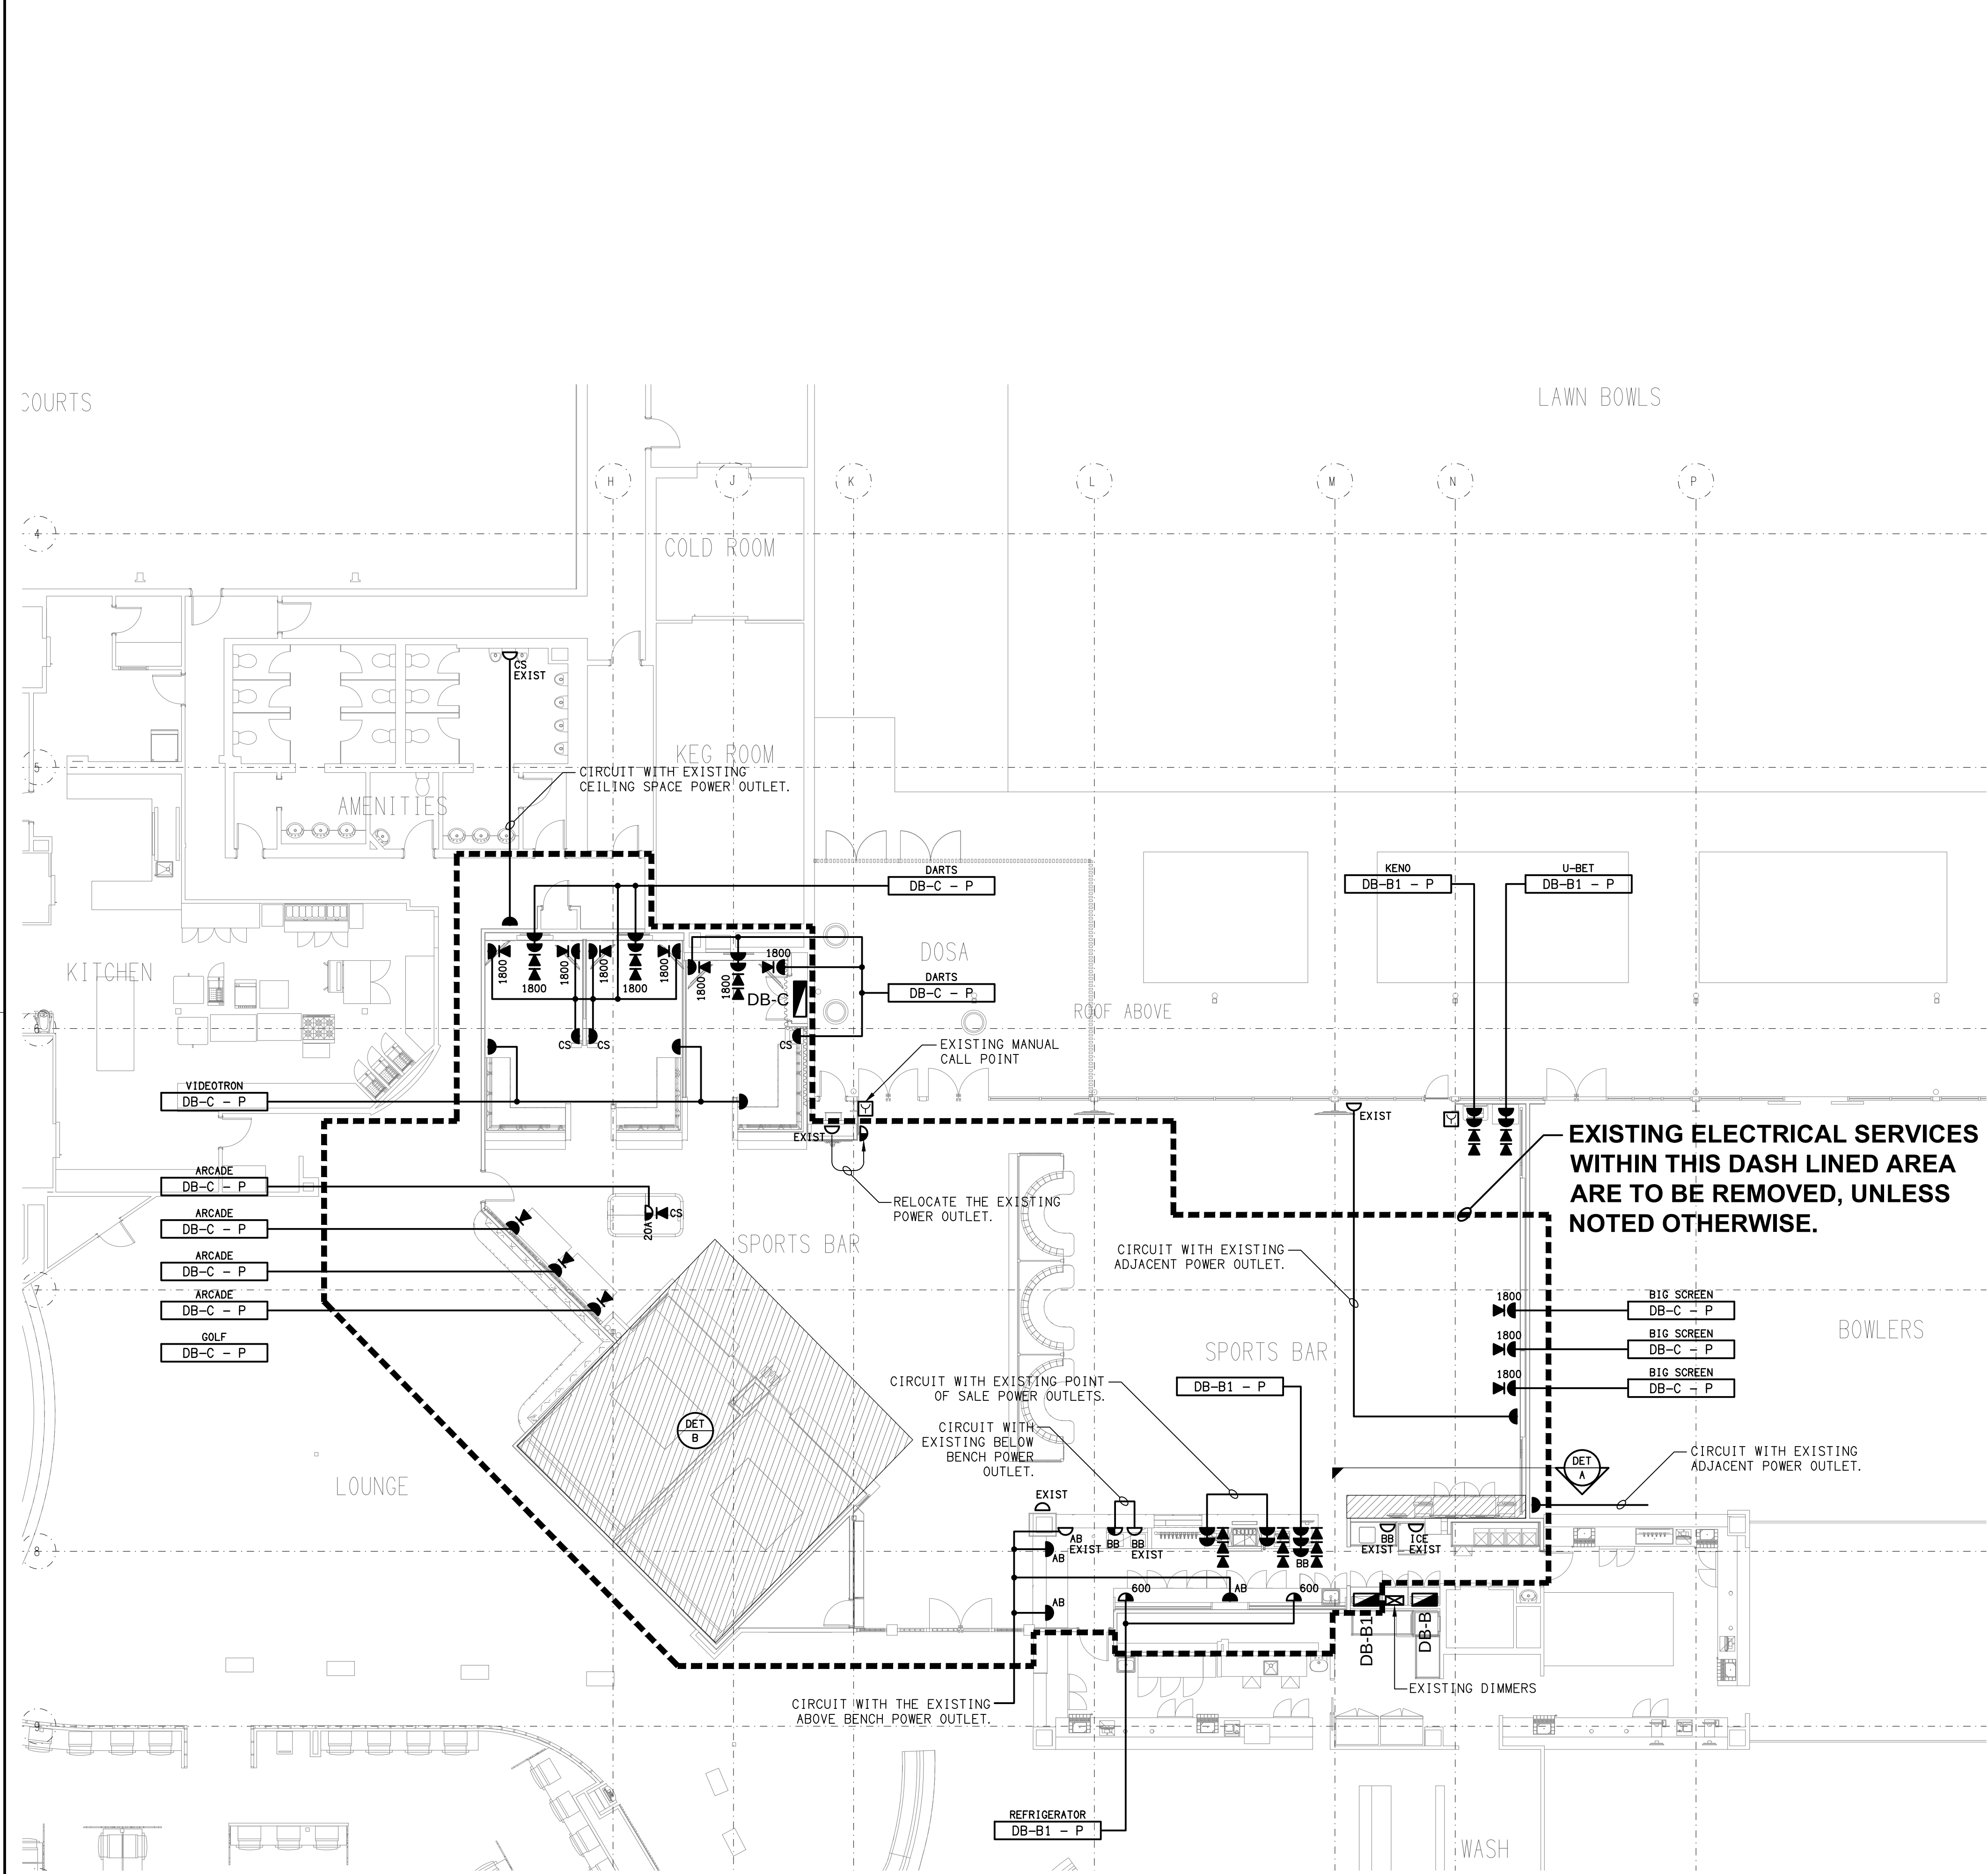

DETAIL A
TAB WALL ELEVATION
SCALE 1: 25

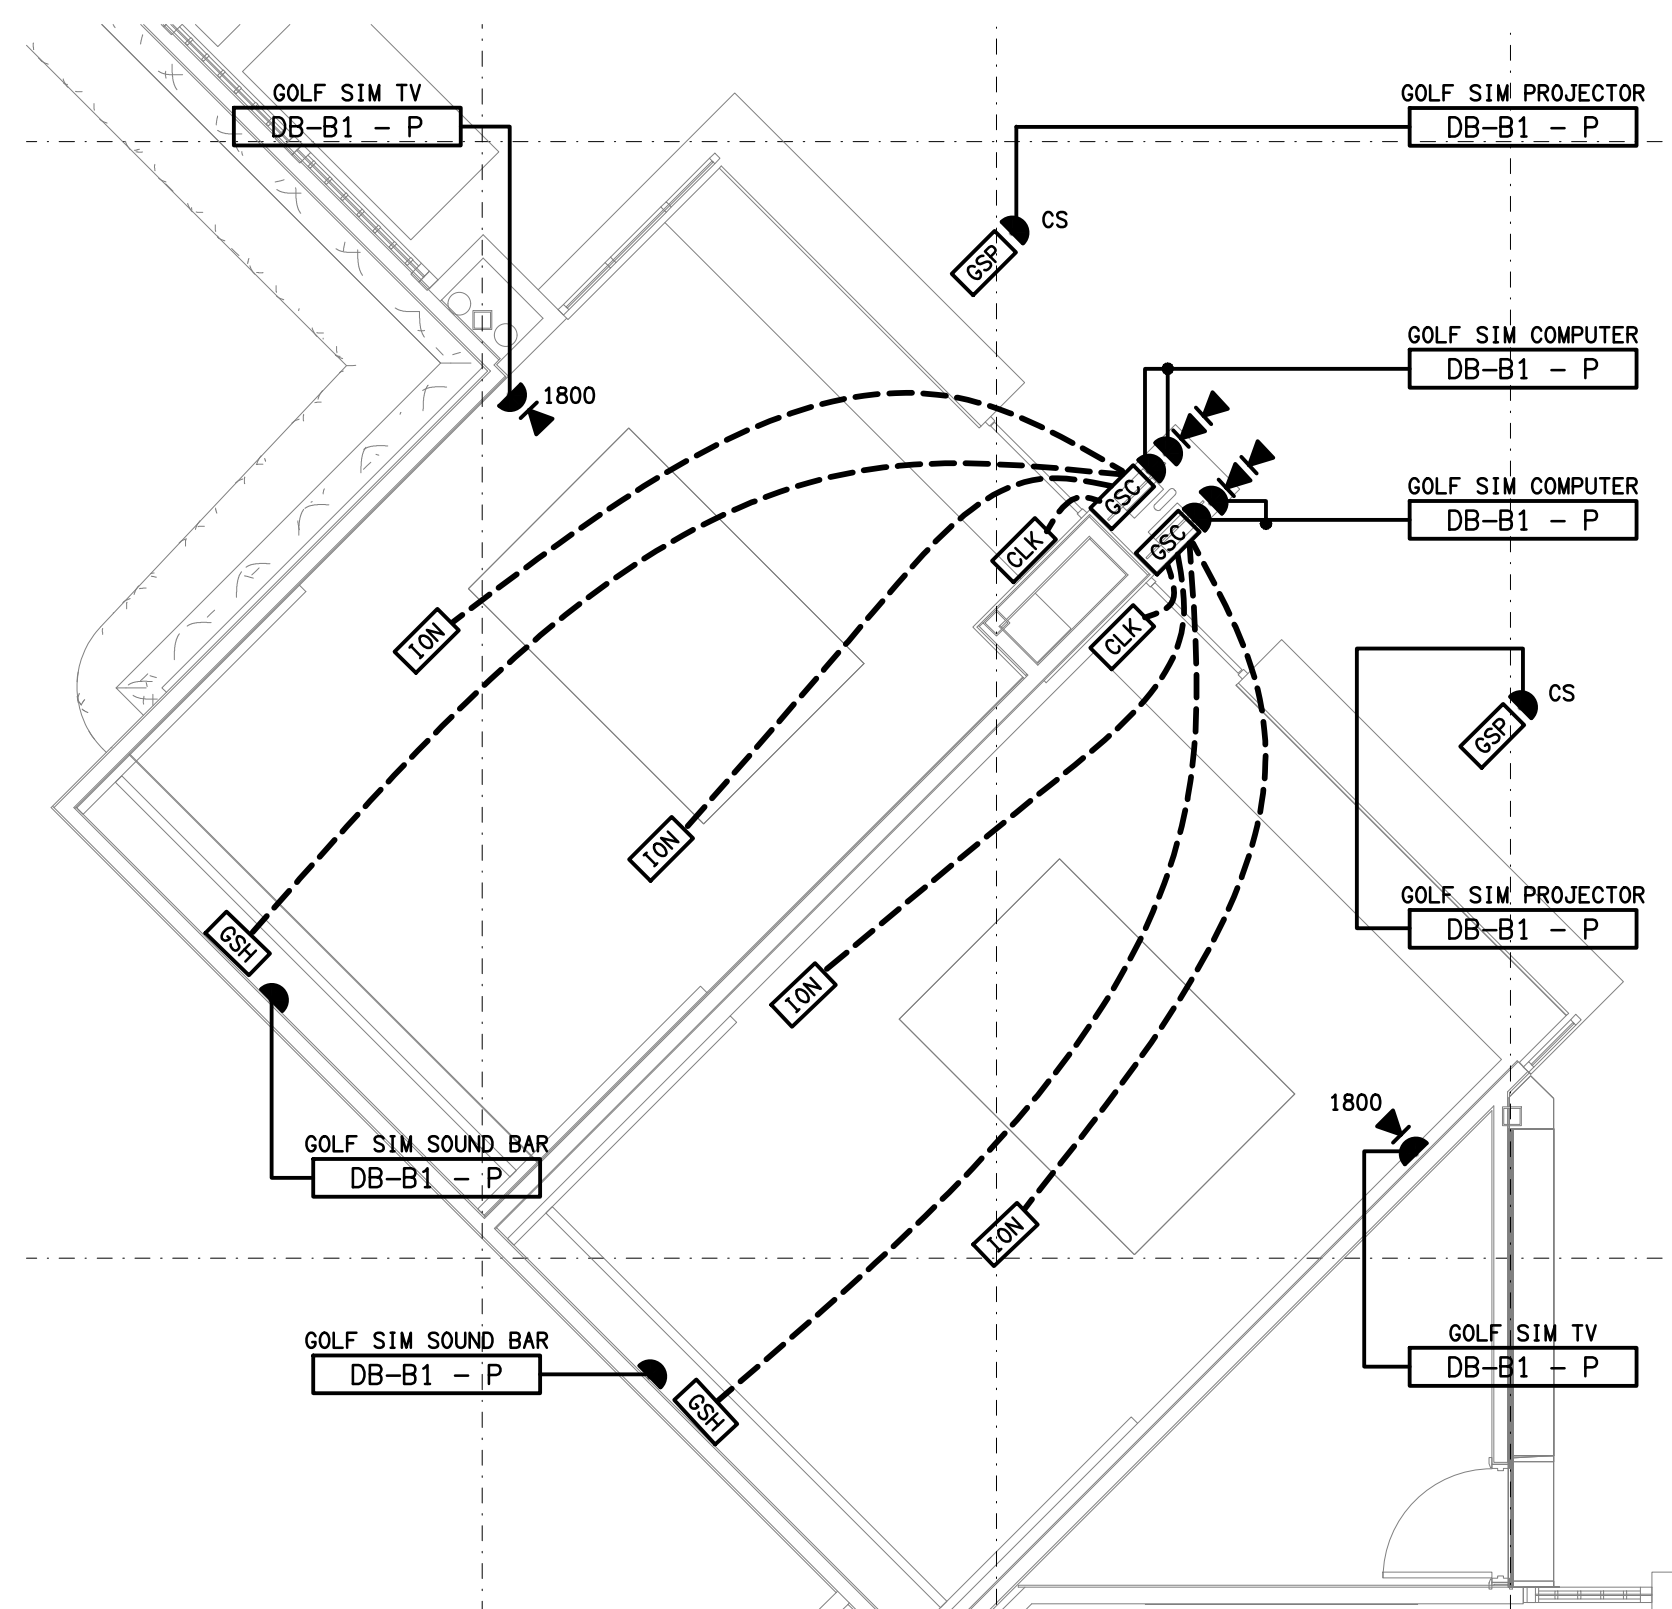

DETAIL B
GOLF SIMULATORS PLAN
SCALE 1: 50

ELECTRICAL DESIGN GROUP BRISBANE
PTY LTD
ACN 092 710 793
TRADING AS:
ELECTRICAL DESIGN GROUP

THE COPYRIGHT OF THIS DRAWING
REMAINS THE PROPERTY OF THE
ELECTRICAL DESIGN GROUP.
USE FIGURED DIMENSIONS
IN PREFERENCE TO SCALE.
ALL DIMENSIONS TO BE
VERIFIED ONSITE.

ELECTRICAL DESIGN GROUP
ELECTRICAL BUILDING SERVICES CONSULTANTS
BRISBANE GOLD COAST

P.O.Box 15, Sherwood Qld 4075
Phone: 0418 893 338
Email: brisbane@edg.net.au
Web: www.edg.net.au

PROJECT:
REDLANDS SPORTING CLUB - STAGE 2

ANSON ROAD, WELLINGTON POINT, QUEENSLAND

A	PRELIMINARY	18/09/2026
REV:	DESCRIPTION:	DATE:

DRAWING:
**ELECTRICAL SERVICES
FLOOR PLAN**

SCALE:
1:100 UNO AT A1

PROJECT NO:
C3763a

DRAWING NO:
E03

REVISION:
A