


NOTE:
REFER TO DRAWING C3843a-E05.dwg FOR THE
ADDITIONAL JOINERY & WALL LIGHTING PLAN.

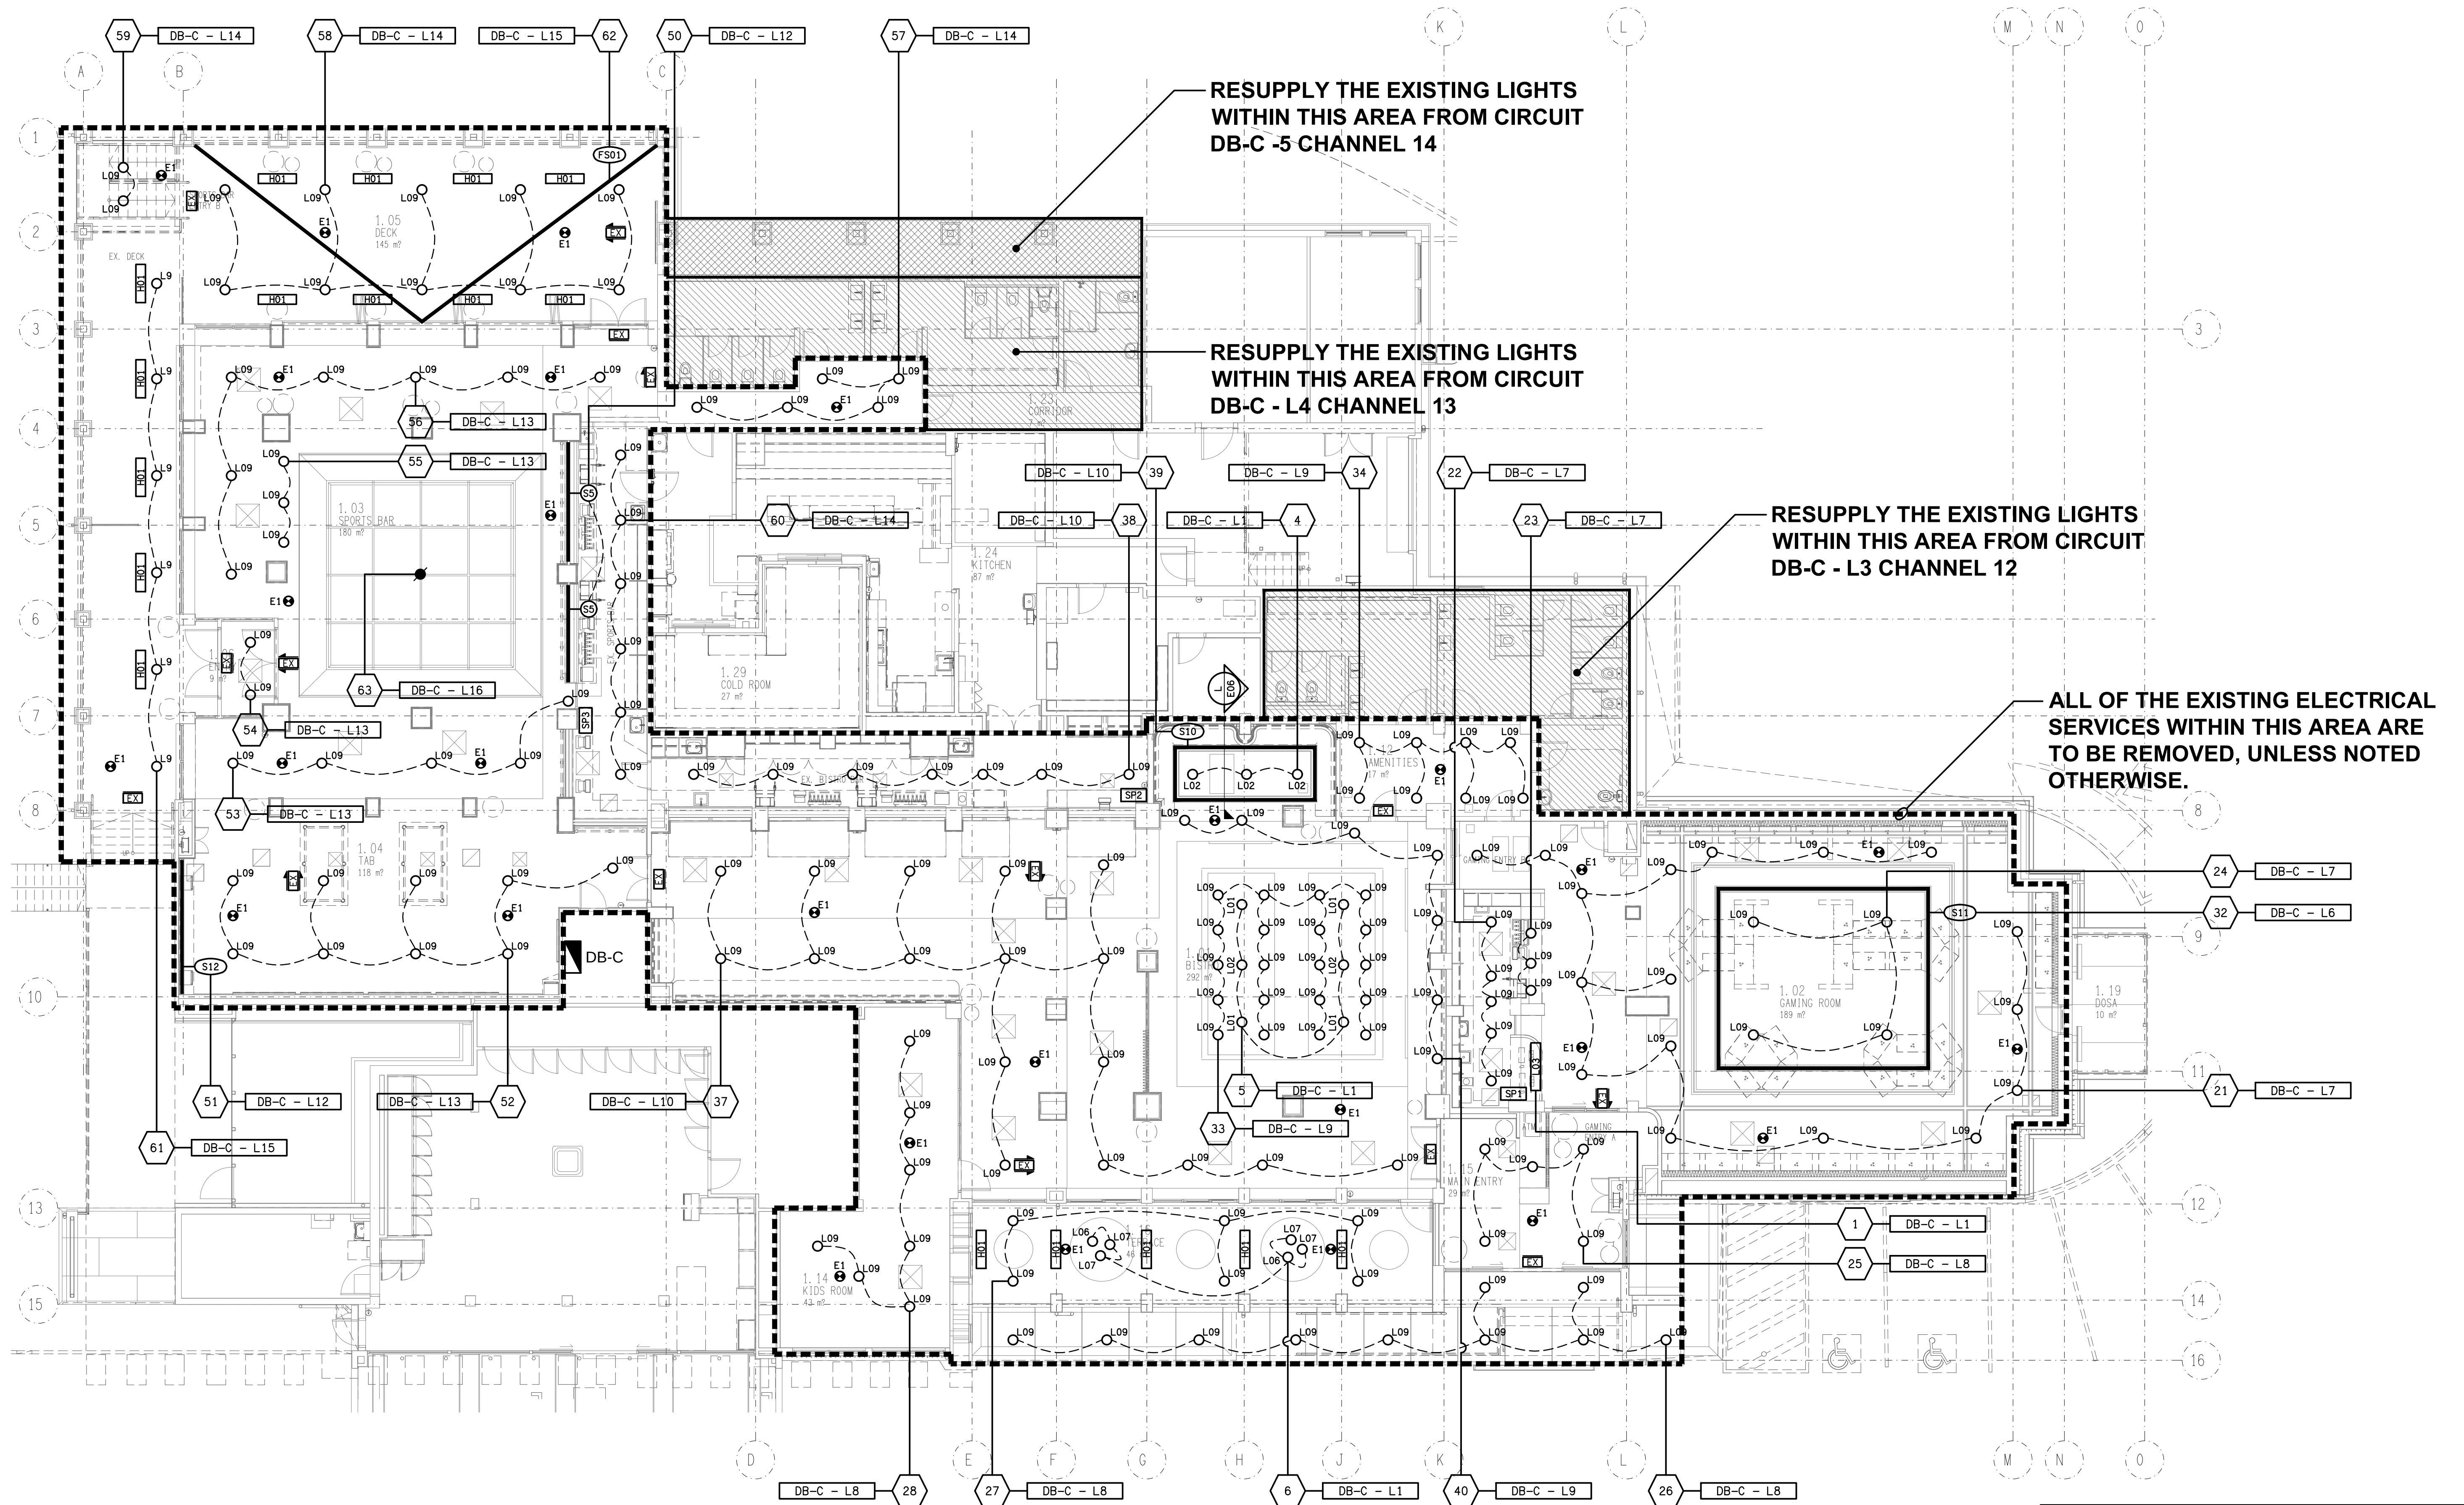

ELECTRICAL DESIGN GROUP BRISBANE PTY LTD ACN 092 710 793 TRADING AS: ELECTRICAL DESIGN GROUP	THE COPYRIGHT OF THIS DRAWING REMAINS THE PROPERTY OF THE ELECTRICAL DESIGN GROUP. USE FIGURED DIMENSIONS IN PREFERENCE TO SCALE. ALL DIMENSIONS TO BE VERIFIED ONSITE.	ELECTRICAL DESIGN GROUP ELECTRICAL BUILDING SERVICES CONSULTANTS BRISBANE GOLD COAST P.O.Box 15, Sherwood Q.4075 Phone: (07) 3278 4375 Email: brisbane@edg.net.au Web: www.edg.net.au	PROJECT: CAPALABA TAVERN 30 OLD CLEVELAND ROAD, CAPALABA, QUEENSLAND	DRAWING: ELECTRICAL SERVICES REFLECTED CEILING PLAN SCALE: 1:100 UNO AT A1 PROJECT NO: C3843a DRAWING NO: E04 REVISION: B
--	--	---	--	---