



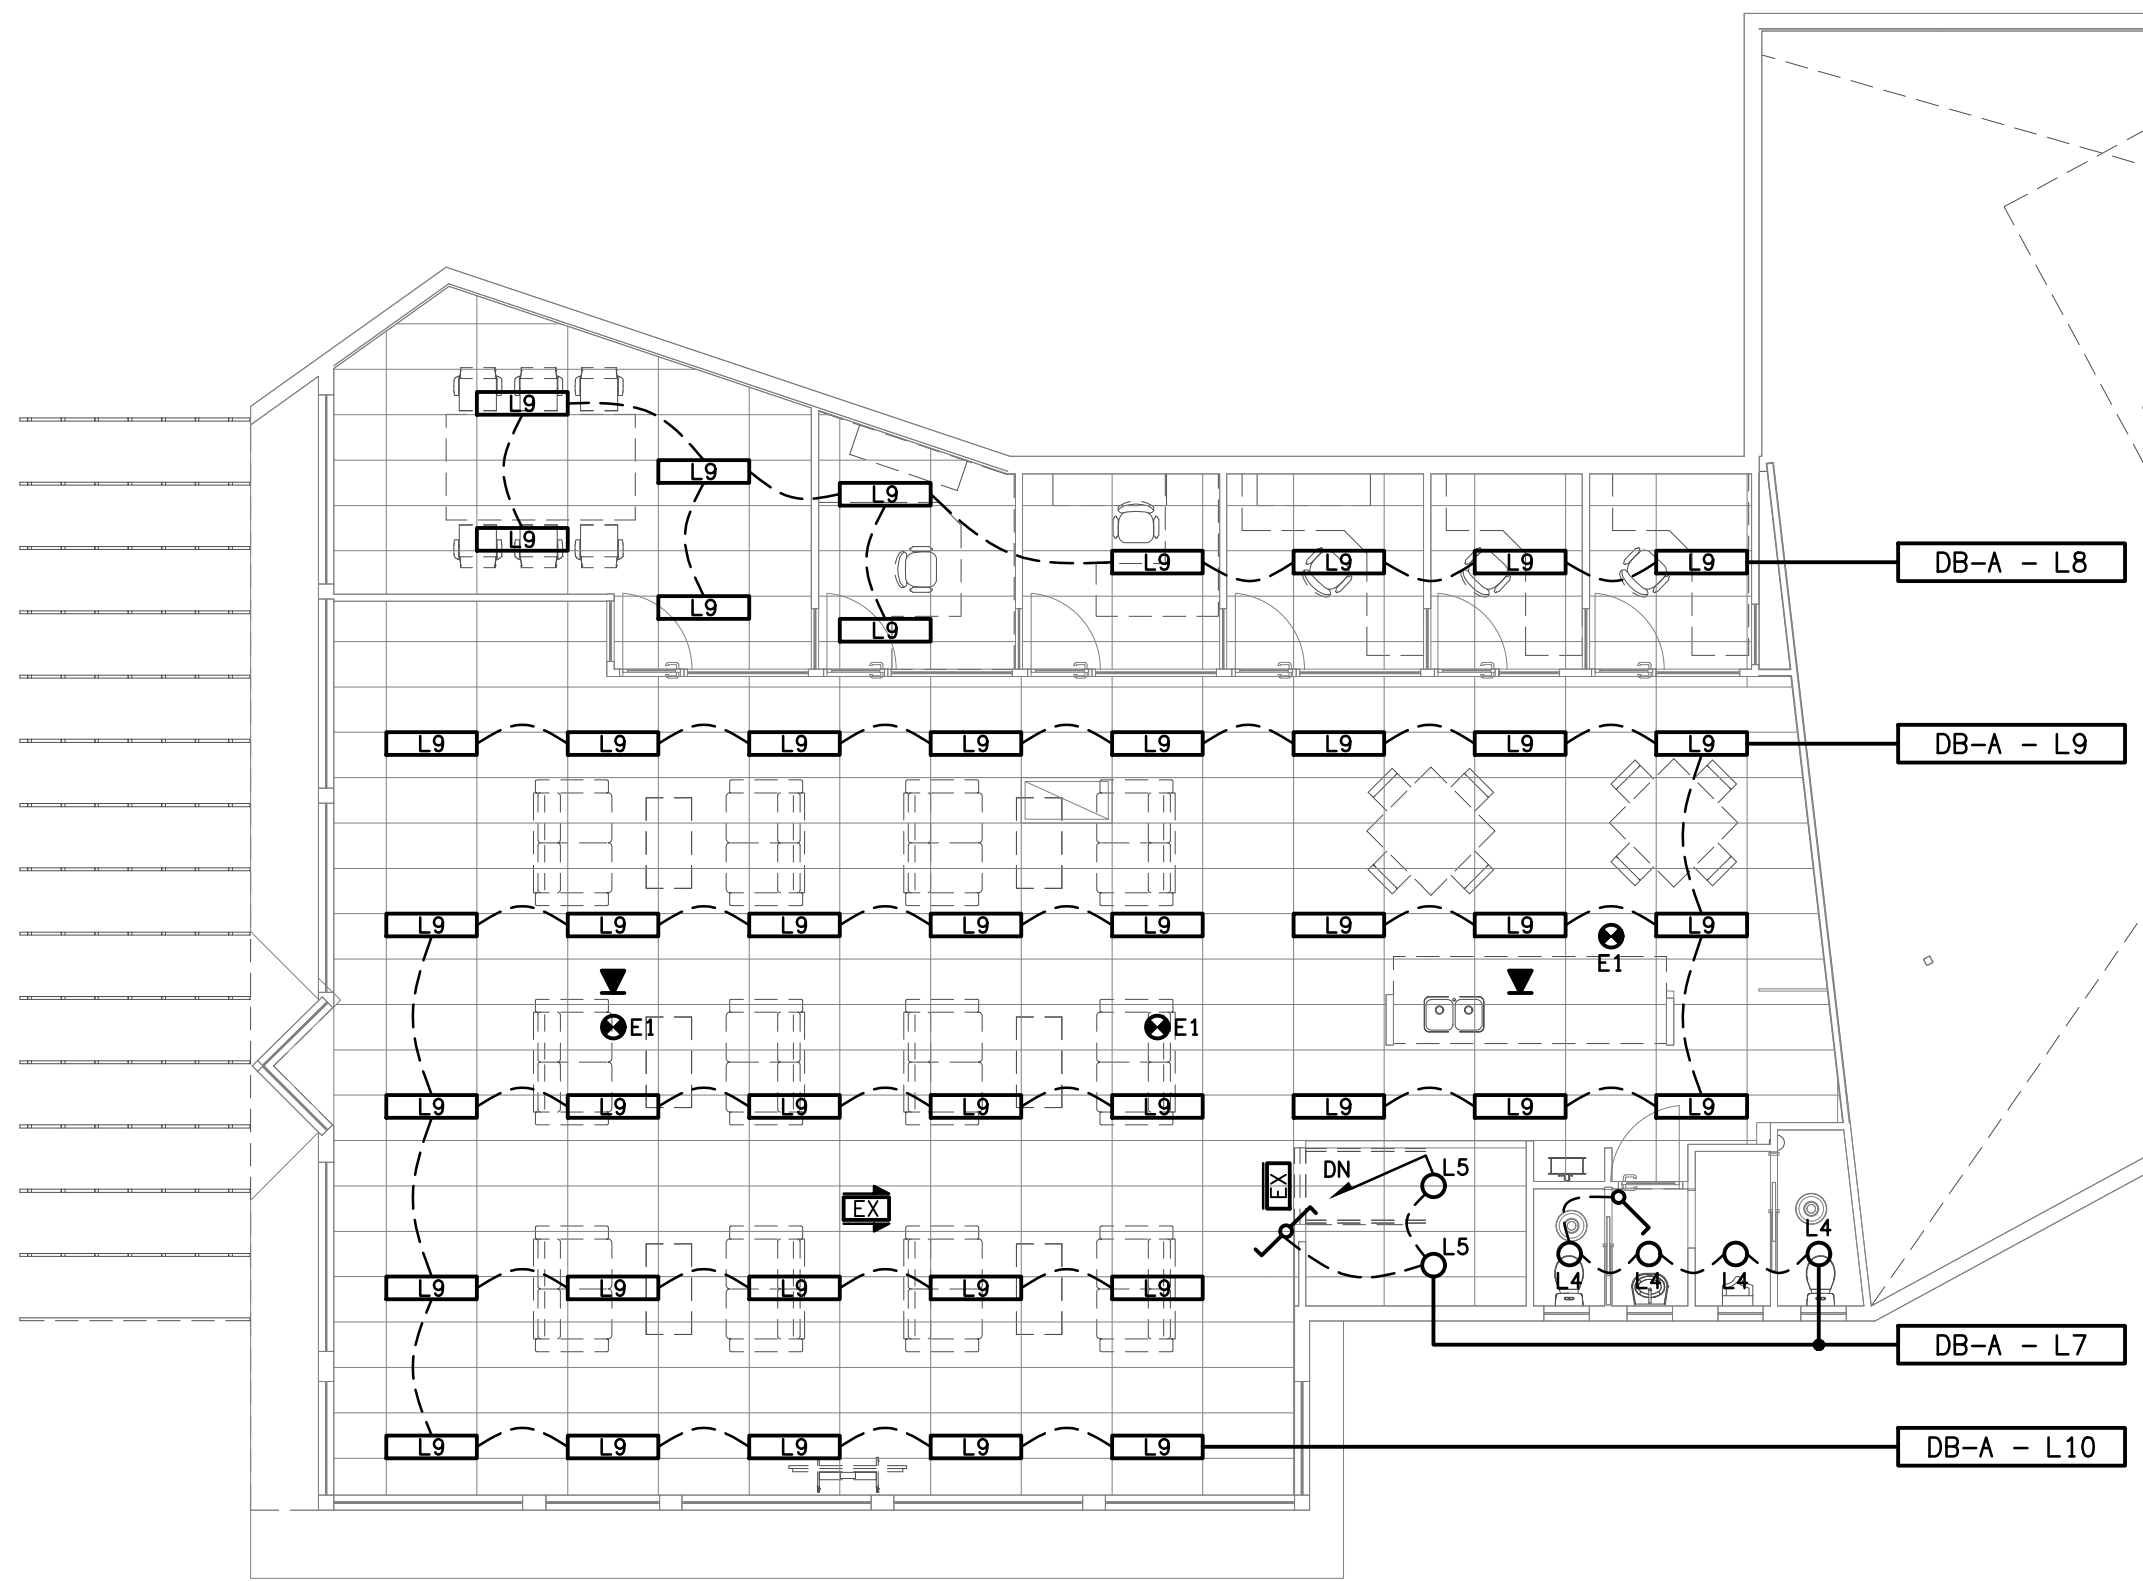

**REFLECTED CEILING PLAN**  
LEVEL 1  
SCALE 1: 100

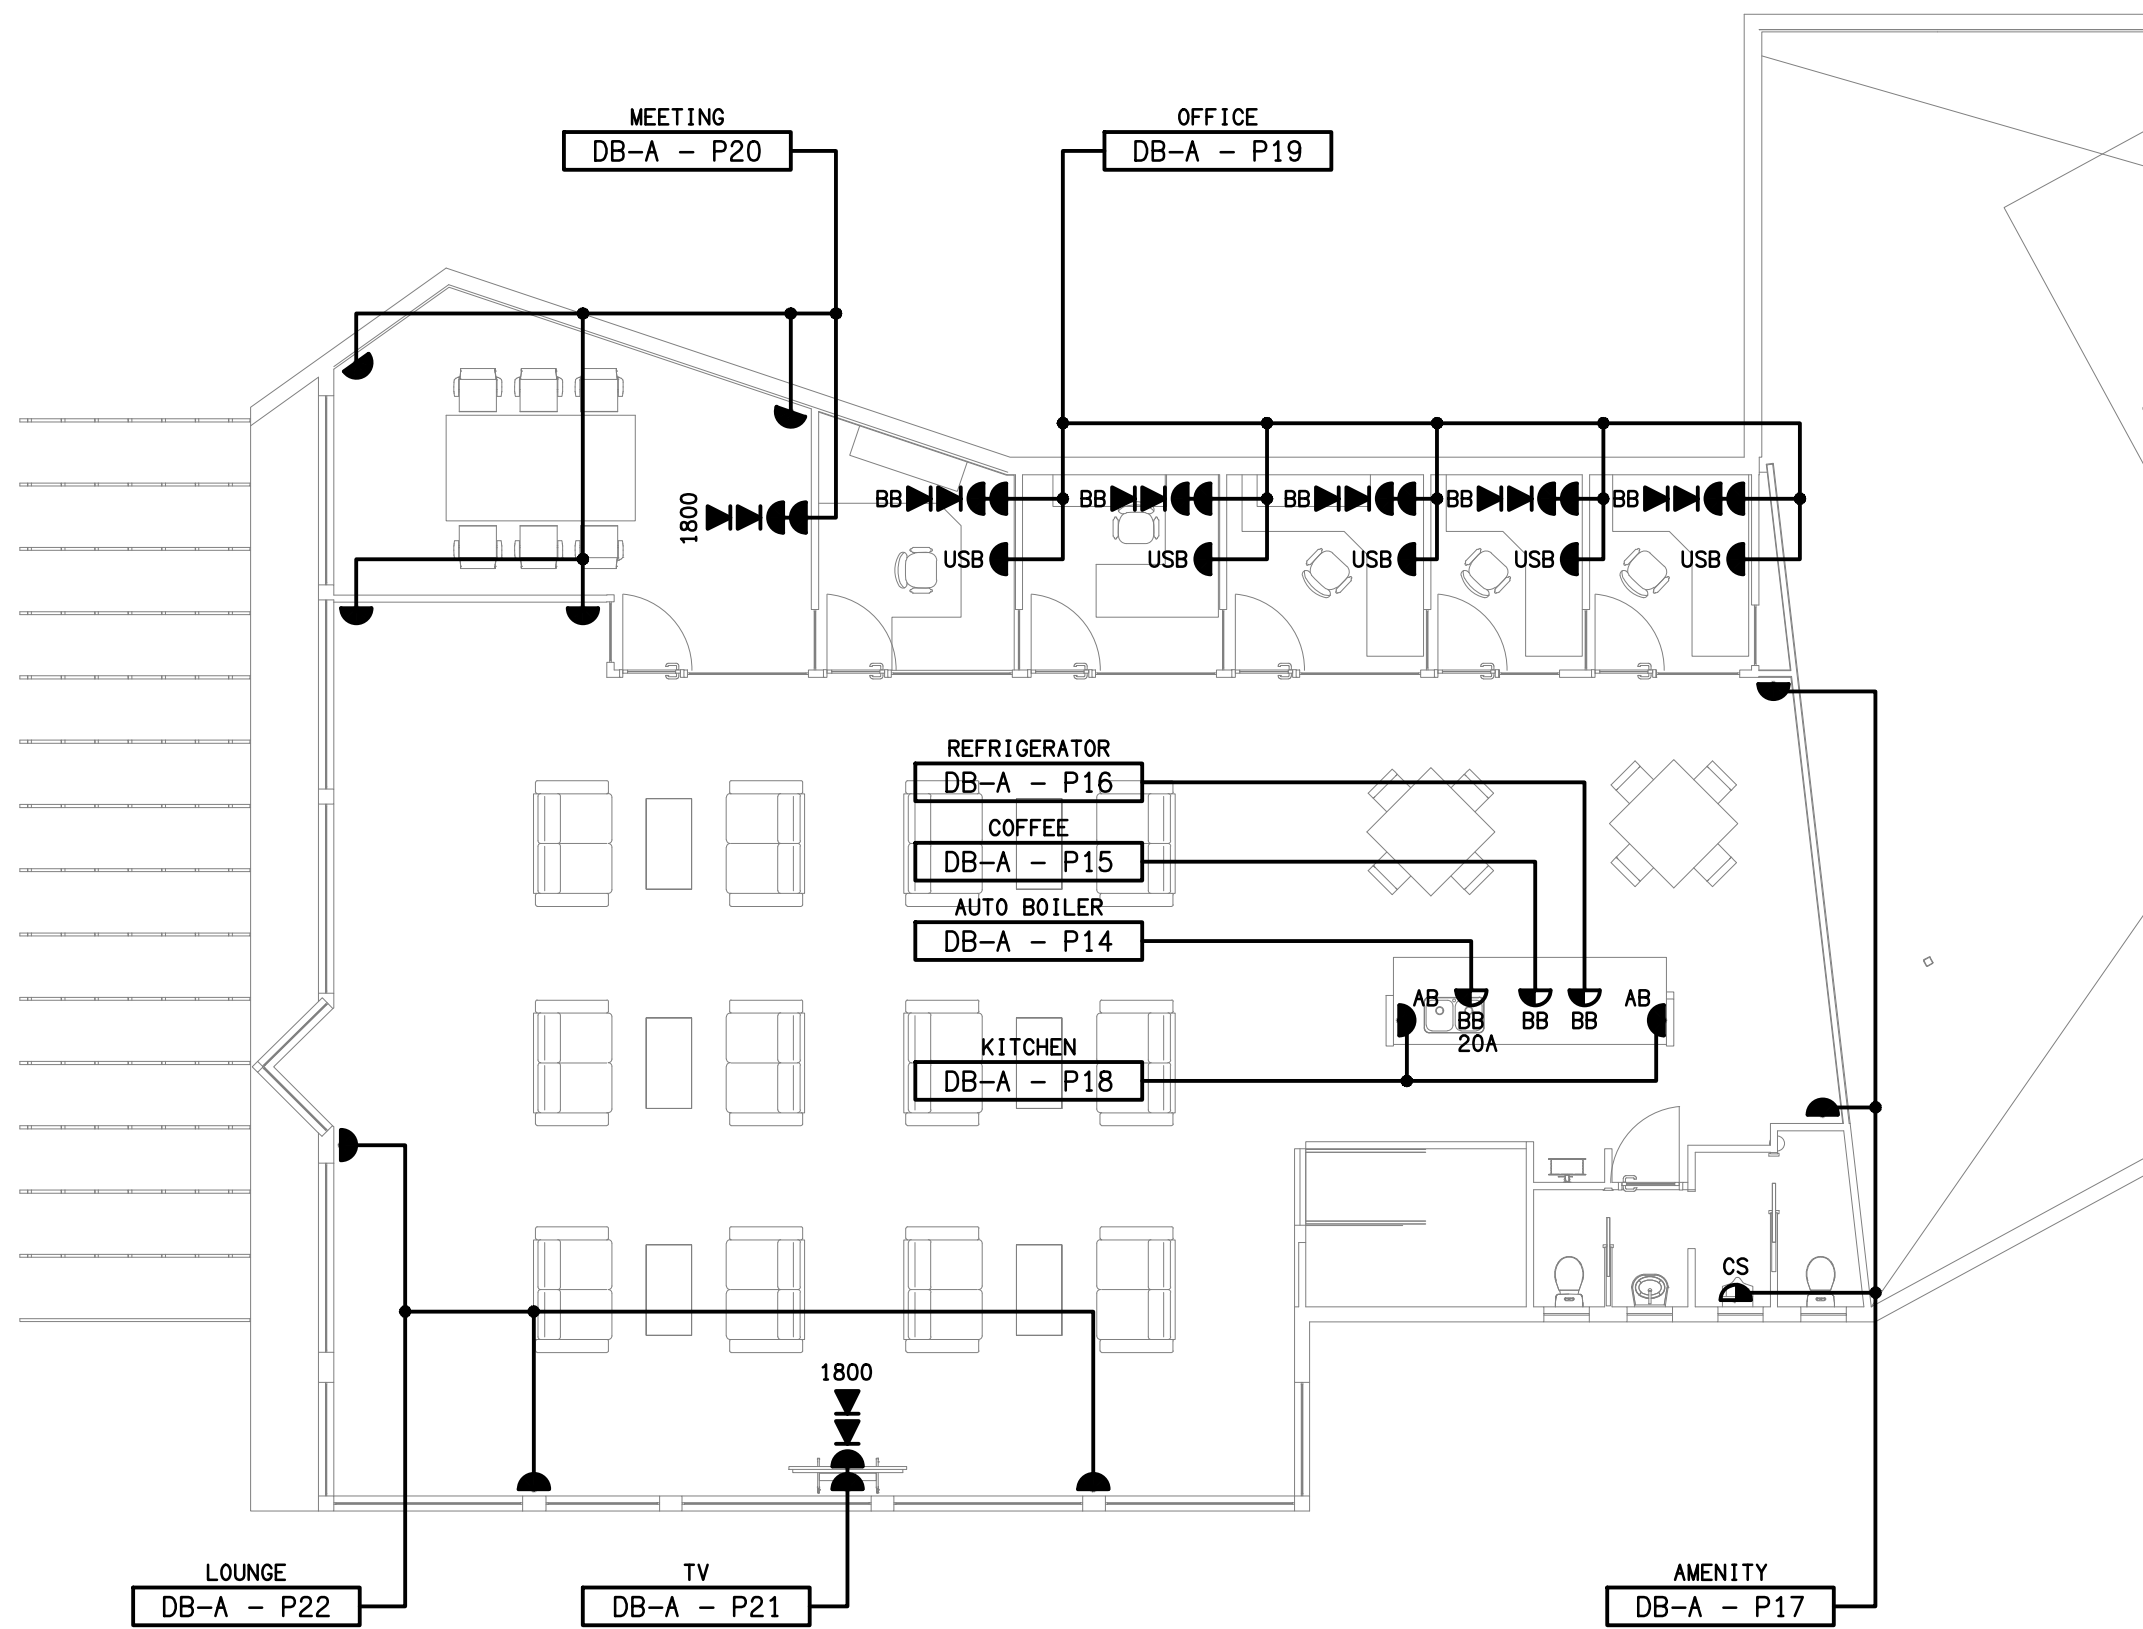

**FLOOR PLAN**  
LEVEL 1  
SCALE 1: 100

ELECTRICAL DESIGN GROUP BRISBANE  
PTY LTD  
ACN 092 710 793  
TRADING AS:  
ELECTRICAL DESIGN GROUP

THE COPYRIGHT OF THIS DRAWING  
REMAINS THE PROPERTY OF THE  
ELECTRICAL DESIGN GROUP.  
USE FIGURED DIMENSIONS  
IN PREFERENCE TO SCALE.  
ALL DIMENSIONS TO BE  
VERIFIED ONSITE.

**ELECTRICAL DESIGN GROUP**  
ELECTRICAL BUILDING SERVICES CONSULTANTS  
BRISBANE GOLD COAST  
P.O.Box 15, Sherwood Q.4075  
Phone: 0418 893 338  
Email: brisbane@edg.net.au  
Web: www.edg.net.au

PROJECT:  
248 ABBOTSFORD ROAD, BOWEN HILLS  
BRISBANE

| A INFORMATION                                            |              | 18/09/2026                                                                         |
|----------------------------------------------------------|--------------|------------------------------------------------------------------------------------|
| REV.                                                     | DESCRIPTION: | DATE:                                                                              |
| DRAWING:<br><b>ELECTRICAL SERVICES<br/>LEVEL 1 PLANS</b> |              |                                                                                    |
| SCALE:<br>1:100                                          | AT A1        | PROJECT NO:<br><b>C3853a</b><br>DRAWING NO:<br><b>E04</b><br>REVISION:<br><b>A</b> |