


B2 CABINET - LED LIGHTING

ELECTRICAL CONTRACTOR TO SUPPLY AND INSTALL LIGHTING


FRONT ELEVATION

SUPPLIER: TREND LIGHTING ORDER CODE: XF24120B3-EXM

DESCRIPTION: 5 x 1740mm LONG, 24V 8W/m LOW WATTAGE LED STRIP, 3000K c/w ALUMINIUM MAGNETIC EXTRUSION, OPAL DIFFUSER, LED DRIVER, 3m LEAD

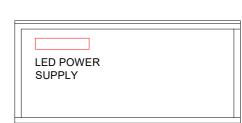


PLAN

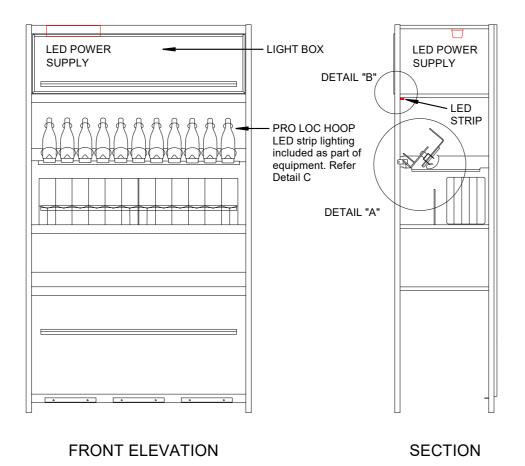

M WALL BAYS - WOTW - LED LIGHTING

ELECTRICAL CONTRACTOR TO SUPPLY AND INSTALL LIGHTING SUPPLIER: TREND LIGHTING

ORDER CODE: XF24120B3-EXM DESCRIPTION: 1 x 1240mm LONG, 24V 8W/m LOW WATTAGE LED STRIP, 3000K c/w ALUMINIUM MAGNETIC EXTRUSION, OPAL DIFFUSER, LED DRIVER, 3m LEAD

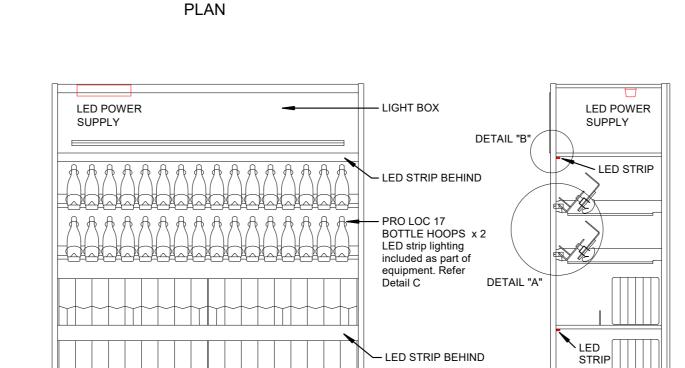

LED POWER SUPPLY


SECTION FRONT ELEVATION

ELECTRICAL CONTRACTOR TO SUPPLY AND INSTALL LIGHTING

B28 CABINET - LED LIGHTING

SUPPLIER: TREND LIGHTING ORDER CODE: XF24120B3-EXM DESCRIPTION: 3 x 1740mm LONG, 24V 8W/m LOW WATTAGE LED STRIP, 3000K c/w ALUMINIUM MAGNETIC EXTRUSION, OPAL DIFFUSER, LED DRIVER, 3m LEAD

LED STRIP BEHIND

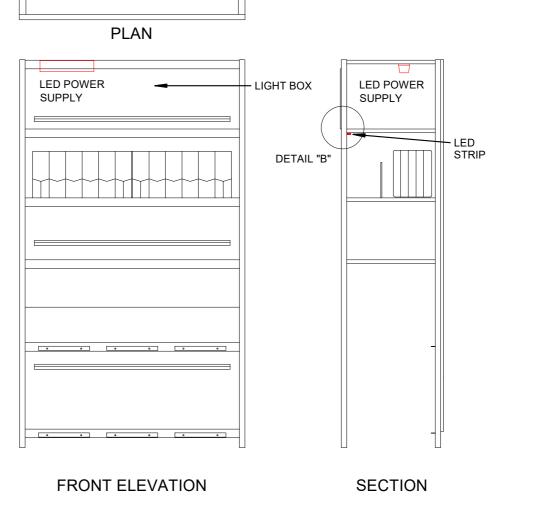

M WALL BAYS - LED LIGHTING

LED POWER

SUPPLY

ELECTRICAL CONTRACTOR TO SUPPLY AND INSTALL LIGHTING

SUPPLIER: TREND LIGHTING ORDER CODE: XF24120B3-EXM DESCRIPTION: 1 x 1240mm LONG, 24V 8W/m LOW WATTAGE LED STRIP, 3000K

c/w ALUMINIUM MAGNETIC EXTRUSION, OPAL DIFFUSER, LED DRIVER, 3m LEAD

FINE WINE SECURITY WALL BAY - TYPE B

^^^^^

FRONT ELEVATION

SUPPLIER: TREND LIGHTING

ORDER CODE: XF24120B3-EXM DESCRIPTION: 3 x 1240mm LONG, 24V 8W/m LOW WATTAGE LED STRIP, 3000K c/w ALUMINIUM MAGNETIC EXTRUSION, OPAL DIFFUSER, LED DRIVER, 3m LEAD

ELECTRICAL CONTRACTOR TO SUPPLY AND INSTALL LIGHTING

LED POWER SUPPLY


SECURED TO FRAME


LED STRIP MOUNTED


LED STRIP


SECTION

UNDER BOTTLE HOOPS

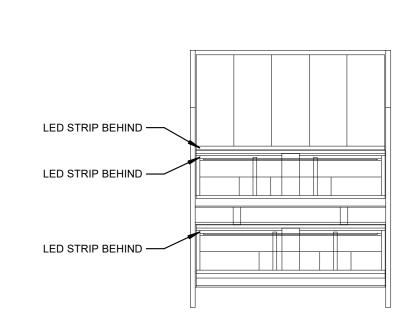


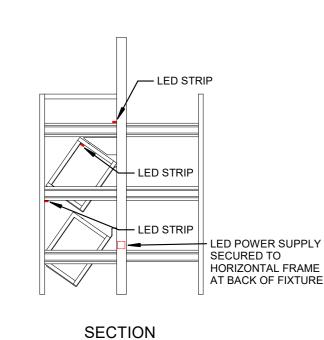


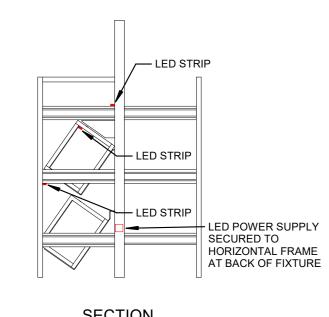


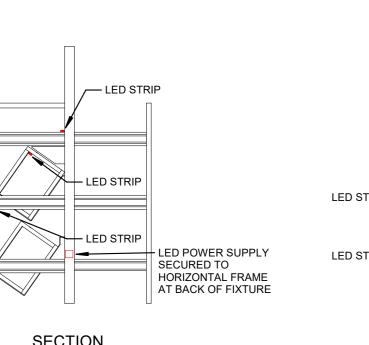



SECTION

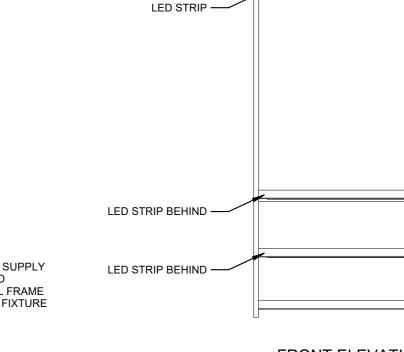


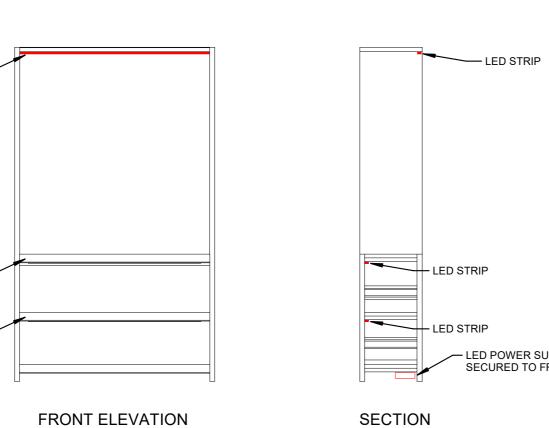

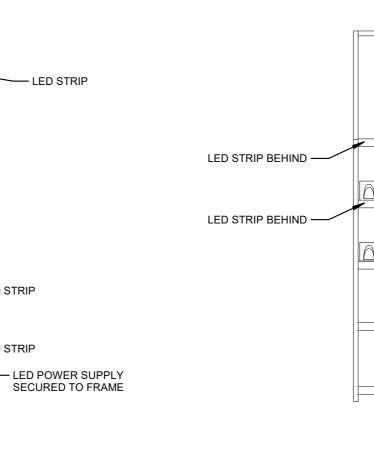

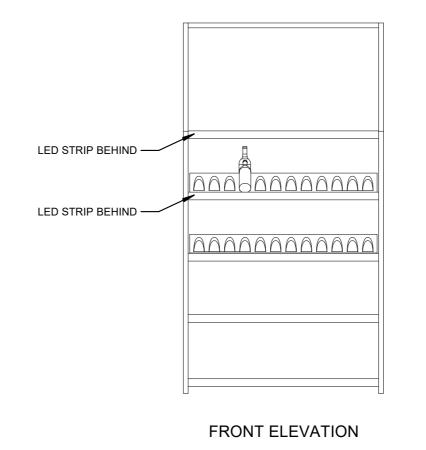

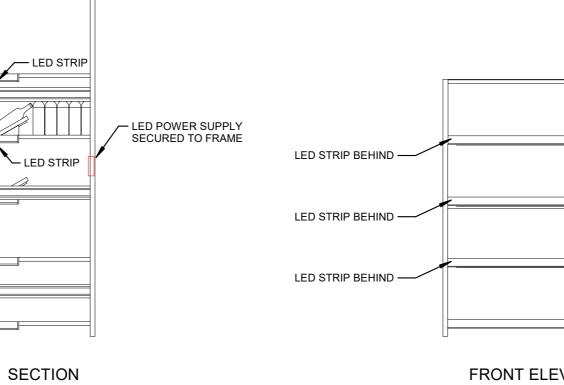

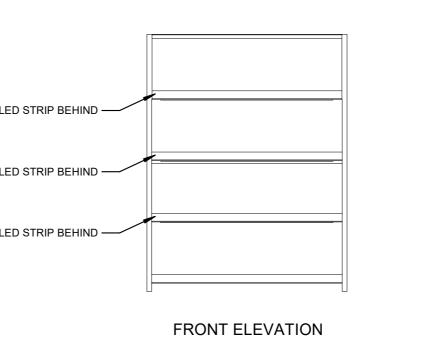

COCKTAIL MIXOLOGY BAY

SUPPLIER: TREND LIGHTING


ORDER CODE: XF24120B3-EXM


CABINET MANUFACTURER TO SUPPLY LIGHTS,


DESCRIPTION: 3 x 1180mm LONG, 24V 8W/m LOW WATTAGE LED STRIP, 3000K

c/w ALUMINIUM MAGNETIC EXTRUSION, OPAL DIFFUSER, LED DRIVER, 3m LEAD

INSTALLATION BY ELECTRICAL CONTRACTOR

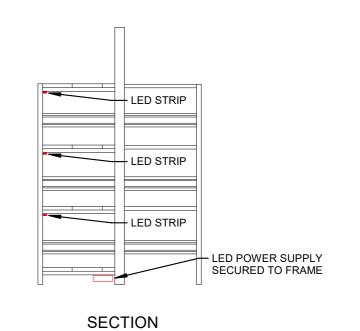

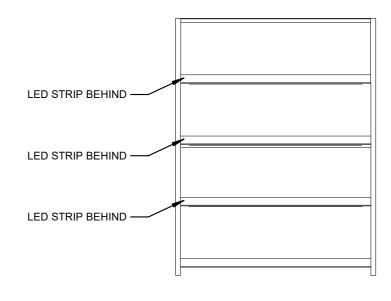

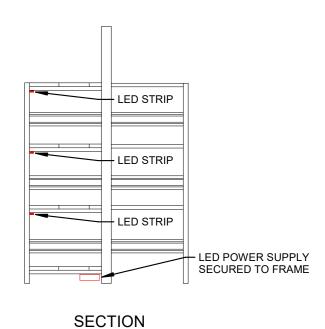

FRONT ELEVATION

LED STRIP BEHIND -

LED STRIP BEHIND —

LED STRIP BEHIND —

GIN BAY ELECTRICAL CONTRACTOR TO SUPPLY AND INSTALL LIGHTING

FOR 2.0 DAN MURPHY'S STORE: 3000K LED LIGHTING

SUPPLIER: TREND LIGHTING ORDER CODE: XF24120B3-EXM DESCRIPTION: 3 x 1240mm LONG, 24V 8W/m LOW WATTAGE LED STRIP, 3000K

c/w ALUMINIUM MAGNETIC EXTRUSION, OPAL DIFFUSER, LED DRIVER, 3m LEAD FOR STANDARD DAN MURPHY'S STORE: CYAN LED LIGHTING

SUPPLIER: TREND LIGHTING ORDER CODE: XFN24C-EXM

DESCRIPTION: 3 x 1240mm LONG, 24V 8W/m LOW WATTAGE LED STRIP, CYAN c/w ALUMINIUM MAGNETIC EXTRUSION, OPAL DIFFUSER, LED DRIVER, 3m LEAD


CELLAR RELEASE BAY

FRONT ELEVATION

CABINET MANUFACTURER TO SUPPLY LIGHTS, INSTALLATION BY ELECTRICAL CONTRACTOR

SUPPLIER: TREND LIGHTING

ORDER CODE: XF24120B3-EXM DESCRIPTION: 3 x 1240mm LONG, 24V 8W/m LOW WATTAGE LED STRIP, 3000K c/w ALUMINIUM MAGNETIC EXTRUSION, OPAL DIFFUSER, LED DRIVER, 3m LEAD

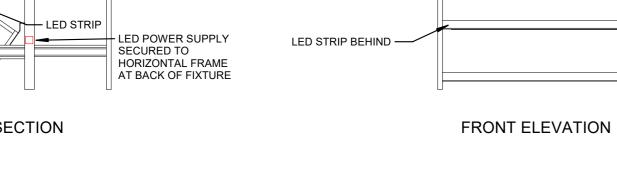


MID FLOOR WARDROBE BAY


CABINET MANUFACTURER TO SUPPLY LIGHTS, INSTALLATION BY ELECTRICAL CONTRACTOR

SUPPLIER: TREND LIGHTING

 ORDER CODE: XF24120B3-EXM DESCRIPTION: 3 x TBDmm LONG, 24V 8W/m LOW WATTAGE LED STRIP, 3000K c/w ALUMINIUM MAGNETIC EXTRUSION, OPAL DIFFUSER, LED DRIVER, 3m LEAD



SUPPLIER: TREND LIGHTING ORDER CODE: XF24120B3-EXM DESCRIPTION: 2 x 1180mm LONG, 24V 8W/m LOW WATTAGE LED STRIP, 3000K c/w ALUMINIUM MAGNETIC EXTRUSION, OPAL DIFFUSER, LED DRIVER, 3m LEAD

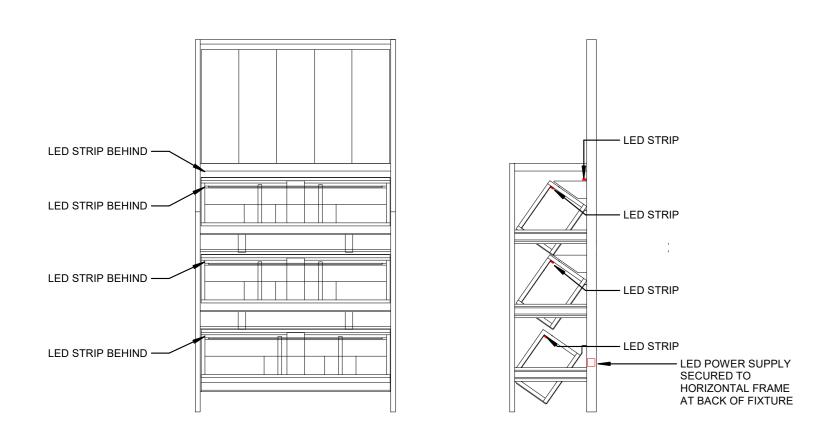

CELLAR RELEASE - WALL BAY


CABINET MANUFACTURER TO SUPPLY LIGHTS,


INSTALLATION BY ELECTRICAL CONTRACTOR SUPPLIER: TREND LIGHTING


FRONT ELEVATION

ORDER CODE: XF24120B3-EXM DESCRIPTION: 4 x 1240mm LONG, 24V 8W/m LOW WATTAGE LED STRIP, 3000K c/w ALUMINIUM MAGNETIC EXTRUSION, OPAL DIFFUSER, LED DRIVER, 3m LEAD

SECTION

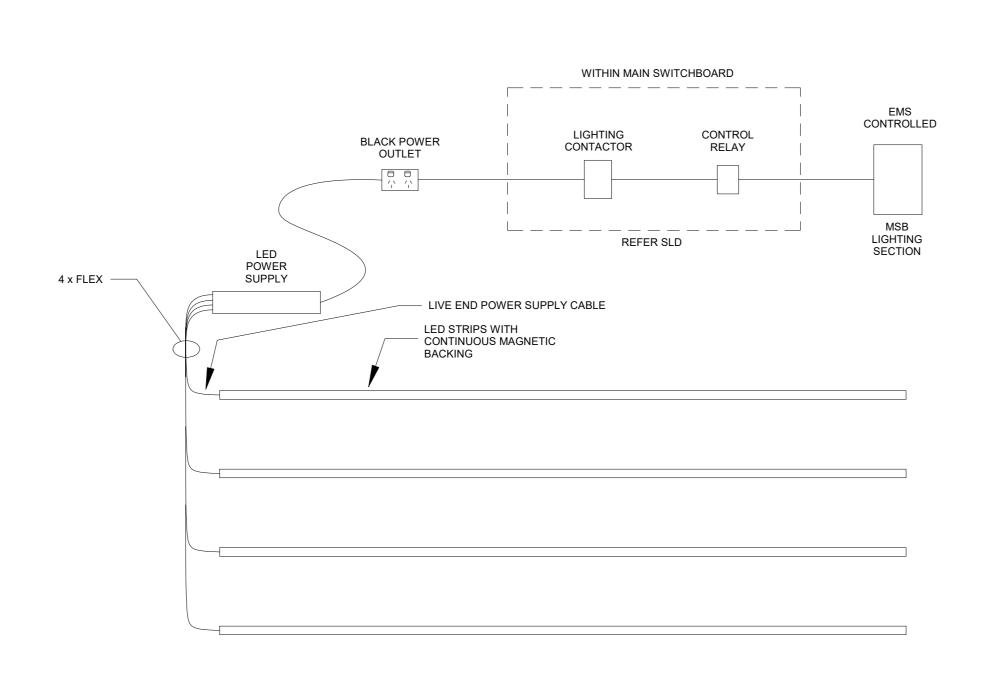

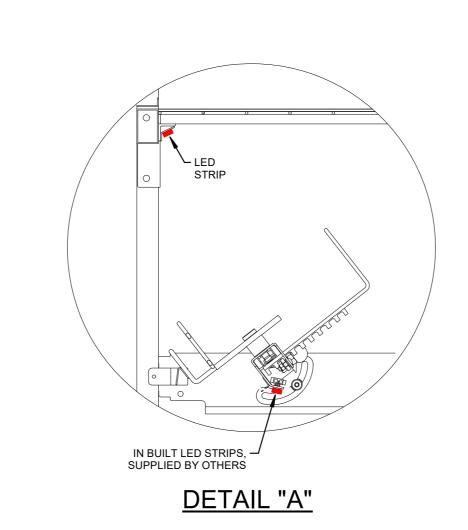

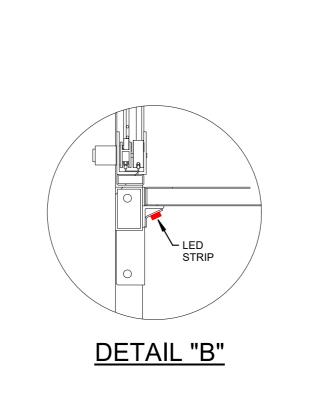

DATE

20/10/21

GENERAL NOTES

1. ELECTRICAL CONTRACTOR TO SUPPLY AND / OR INSTALL UNDERSHELF LED STRIP LIGHTS AS DETAILED FOR EACH CABINET TYPE. INCLUDED IN THE SCOPE IS THE PROVISION OF POWER OUTLETS FOR UNDERSHELF


REFER STORE SPECIFIC ARCHITECTURAL DRAWINGS FOR CABINET

TYPES AND QUANTITIES REQUIRED.



ACN: 159 767 843 - ABN: 77159767843 - LEVEL 1, 26 WATERLOO STREET, SURRY HILLS NSW DISCLAIMER:
COPYRIGHT OF THIS DOCUMENT REMAINS WITH ENDEAVOUR ermission. Ll dimensions, sizes, etc, are in millimeters. **Do not** SCALE DIRECTLY FROM DRAWINGS.
THIS DRAWING IS TO BE READ IN CONJUNCTION WITH
ELECTRICAL, MECHANICAL, HYDRAULIC AND ALL OTHER
RELATED BLUEPRINT DRAWINGS AND CONSTRUCTION
SECSIFIC SUPPRINT DRAWINGS AND CONSTRUCTION ELAIEU BLUEFRINI DAANINGS AND SOLUTIONS.
PECIFICATIONS.
THIS DRAWING IS FOR DESIGN GUIDANCE ONLY, FINAL DETAILS
MUST MEET SITE CONDITIONS, RELEVANT AUTHORITIES,
APPLICABLE AUSTRALIAN BUILDING STANDARDS AND NCC.

REV. REVISION DETAILS

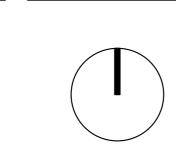

PROJ LEV I
 DRAV
СТ
100115

EDG

PROJECT ADDRESS :		DRAWING NAME:
LEVEL 1, 26 WATERLO	O STREET, SURRY HILLS NSW	LED CABINET LIGHTS
DRAWN BY :	APPROVED BY :	DOC STAGE :
DRAWN BY :	APPROVED BY : ENDEAVOUR GROUP	DOC STAGE : DA200 FITOUT

2022 KIT

SCALE: NTS & AO REGION / STATE ALL KIT VERSION: DRAWING No: **DME608 DM 2022 KIT** STORE No: REVISION: